



Office No. 529,
5th Floor, 680 Hotel Building,
Muindi Mbingu Street,
Off Kenyatta Avenue.
geconsulteam@gmail.com
www.geconsultarchites.com P.O Box 103525 - 00101 Nairobi, Kenya Tel:+254 724 008 839 / +254 725 178 873

**Implementation Partner:** Client:

> SOMALIA STABILIZATION INITIATIVE (SSI)

Project title:


**Grant No.:** 

Content:

GOOF GADUUD **ADMINISTRATION** 

PROPOSED GOOF GUDUUD SUB DISTRICT COMMUNITY CENTRE

**BAI041** 

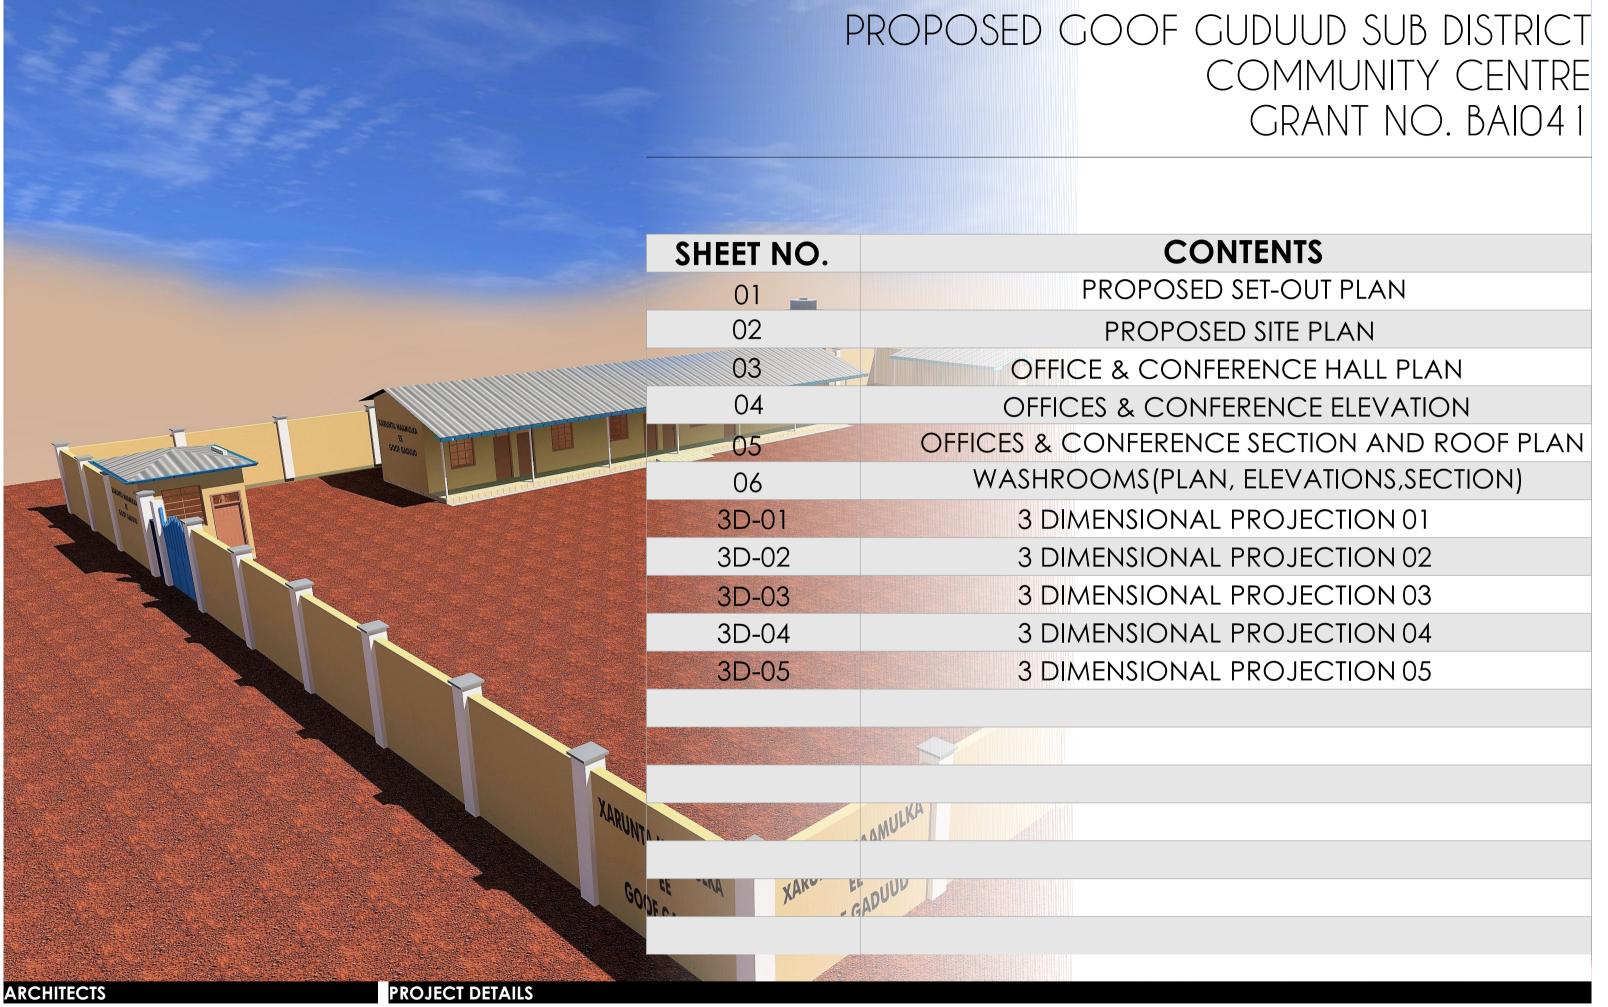



GeConsult

ARCHITECTURE & ENGINEERING CONSULTANTS

Office No. 529,
5th Floor, 680 Hotel Building,
Muindi Mbingu Street,
Off Kenyatta Avenue.
geconsulteam@gmail.com
www.geconsultarchitects.com
P.O Box 103525 - 00101 Nairobi,Kenya
Tel:+254 724 008 839 / +254 725 178 875

Client: Implementation Partner:

Project title:

**Grant No.:** 

Content:

GOOF GADUUD
ADMINISTRATION

SOMALIA STABILIZATION INITIATIVE (SSI)

PROPOSED GOOF GUDUUD SUB DISTRICT COMMUNITY CENTRE

**BAI041** 





GeConsult
ARCHITECTURE & ENGINEERING CONSULTANTS

ARCHITECTURE & ENGINEERING CONS
Office No. 529,
5th Floor, 680 Hotel Building,
Muindi Mbingu Street,
Off Kenyatta Avenue,
geconsulteam@gmail.com
www.geconsultarchitects.com
P.O Box 103525 - 00101 Nairobi,Kenya
Tel;+254 724 008 839 / +254 725 178 875

## PROJECT DETAILS

GOOF GADUUD

**ADMINISTRATION** 

Client:

Implementation Partner:


SOMALIA STABILIZATION IOM International Organization for Migration INITIATIVE (SSI

Project title:

PROPOSED GOOF GUDUUD SUB DISTRICT COMMUNITY CENTRE

awing Tittle:		Revision No.			
GPS COORDINATES		00			
rawn by:	Checked & Approved by	<b>/</b> :	Sheet No.	Scale:	

Hassan Abdisamad A.K. ARCHITECTURAL DRAWINGS May 2017 Date:

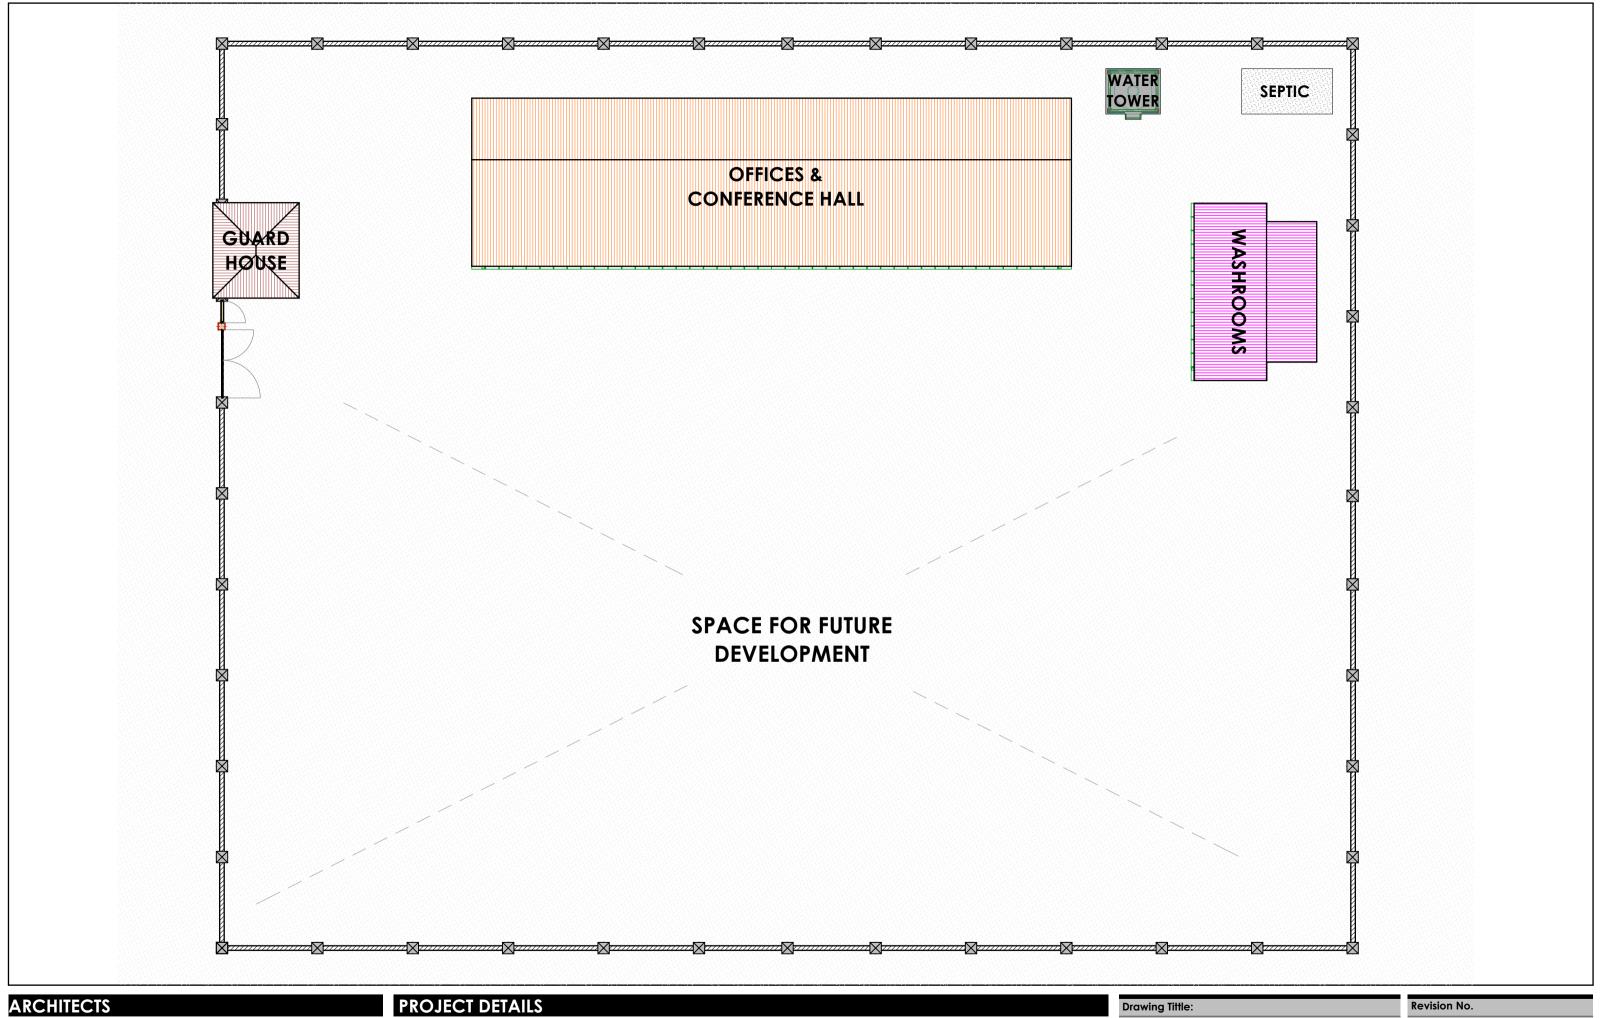



Office No. 529,
Sth Floor, 680 Hotel Building,
Muindi Mbingu Street,
Off Kenyatta Avenue,
geconsulteam@gmail.com
www.geconsultarchitects.com
P.O Box 103525 - 00101 Nairobi,Kenya
Tel:+254 724 008 839 / +254 725 178 875

Implementation Partner: Client:

GOOF GADUUD

**ADMINISTRATION** 

**SOMALIA STABILIZATION** INITIATIVE (SSI)

#### Project title:


PROPOSED GOOF GUDUUD SUB DISTRICT COMMUNITY CENTRE SET-OUT PLAN

00

Scale:

Checked & Approved by: Sheet No. Drawn by: A.K. Hassan Abdisamad

May 2017

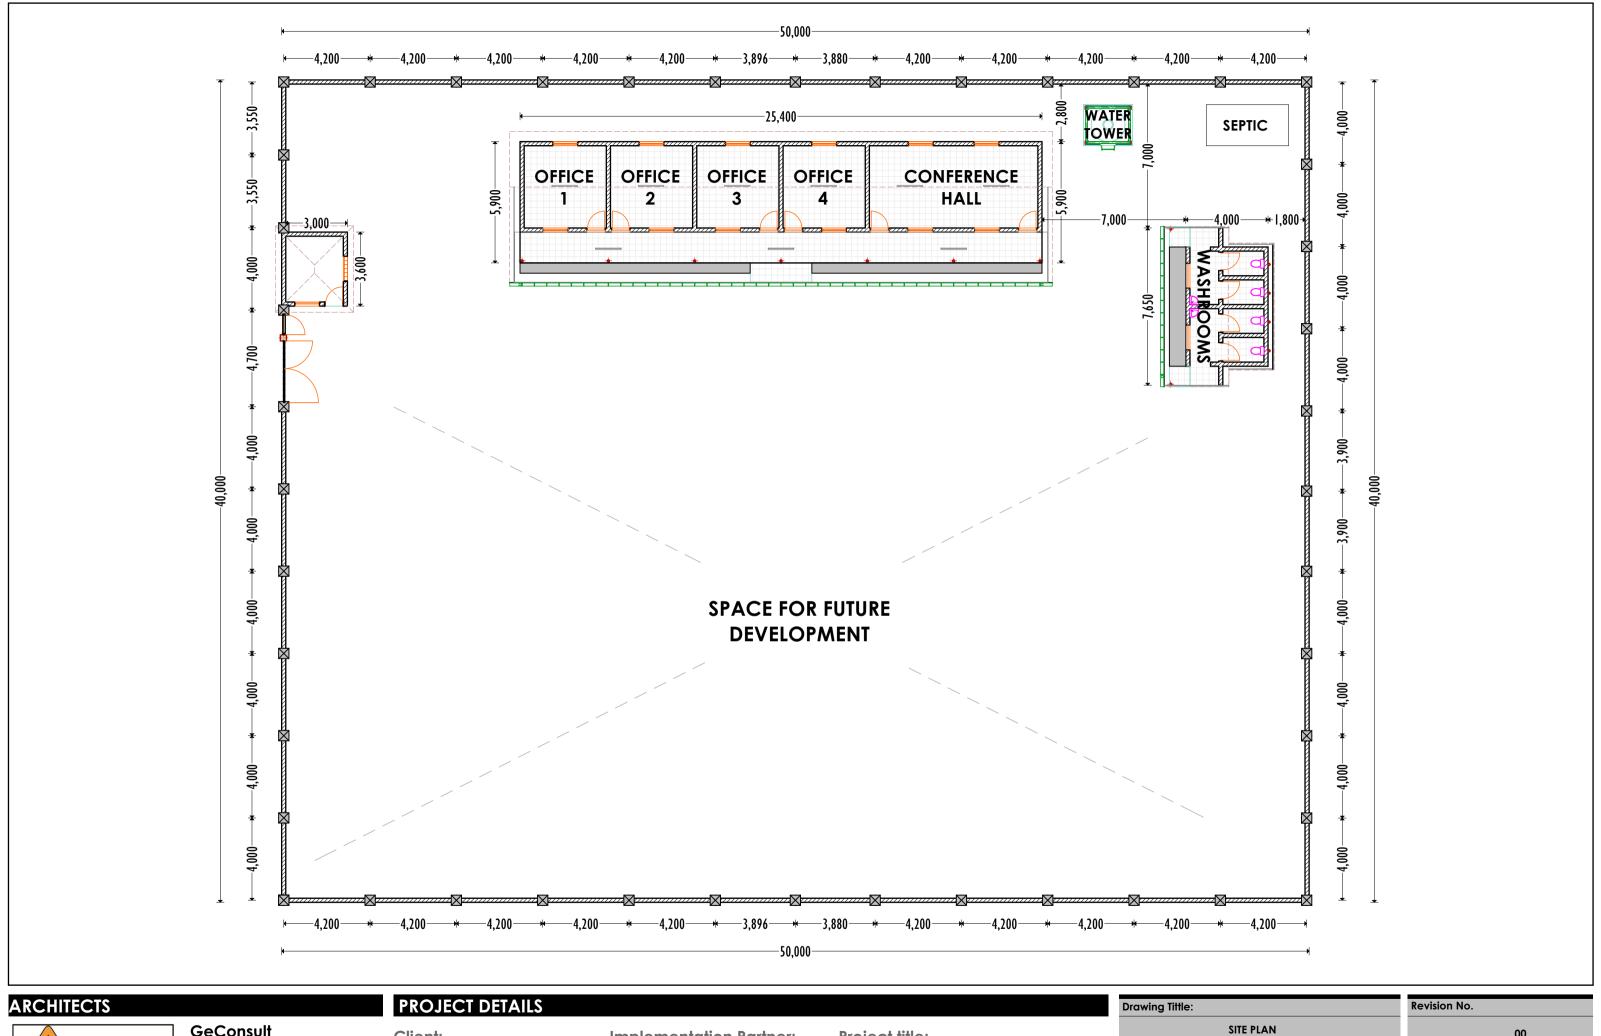



Office No. 529,
Sth Floor, 680 Hotel Building,
Muindi Mbingu Street,
Off Kenyatta Avenue,
geconsulteam@gmail.com
www.geconsultarchitects.com
P.O Box 103525 - 00101 Nairobi,Kenya
Tel:+254 724 008 839 / +254 725 178 875

Client: Implementation Partner:

GOOF GADUUD

**ADMINISTRATION** 

**SOMALIA STABILIZATION** INITIATIVE (SSI)

## PROPOSED GOOF GUDUUD


SUB DISTRICT COMMUNITY CENTRE

Project title:

#### Checked & Approved by: Drawn by: A.K. Hassan Abdisamad **ARCHITECTURAL DRAWINGS** May 2017

Scale: Sheet No.

00

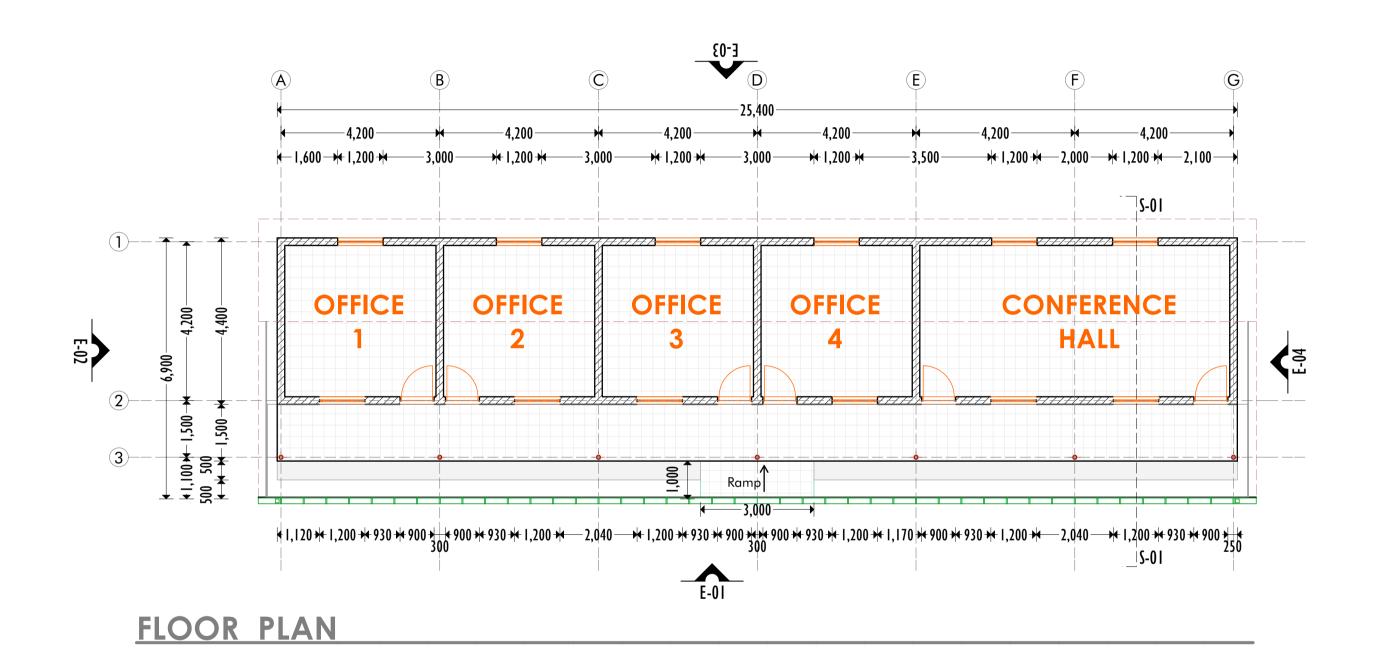



Office No. 529, 5th Floor, 680 Hotel Building, Muindi Mbingu Street,
Off Kenyatta Avenue.
geconsulteam@gmail.com
www.geconsultarchitects.com
P.O Box 103525 - 00101 Nairobi,Kenya
Tel:+254 724 008 839 / +254 725 178 875

## **PROJECT DETAILS**

GOOF GADUUD

**ADMINISTRATION** 


Client: Implementation Partner:

**INITIATIVE (SSI)** 

**SOMALIA STABILIZATION** PROPOSED GOOF GUDUUD SUB DISTRICT COMMUNITY CENTRE

**Project title:** 

#### Revision No. **OFFICE & CONFERENCE HALL PLAN** 00 Scale: Sheet No. Checked & Approved by: Drawn by: A.K. Hassan Abdisamad **ARCHITECTURAL DRAWINGS** May 2017

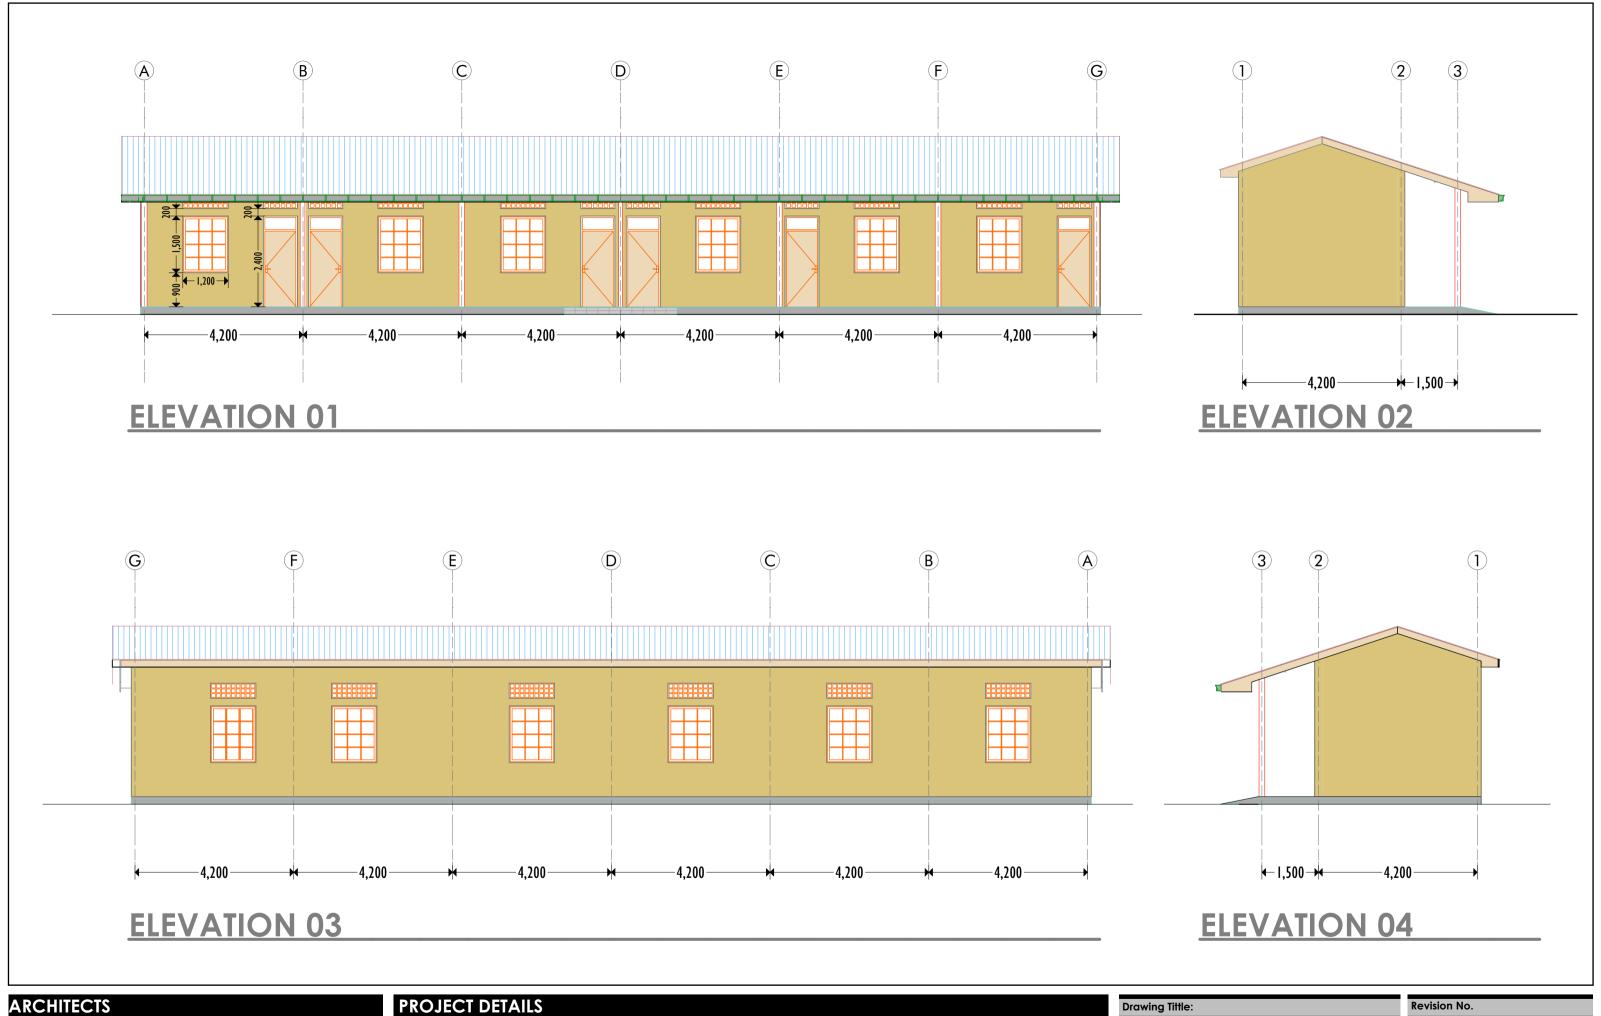



Office No. 529, 5th Floor, 680 Hotel Building, Muindi Mbingu Street, Off Kenyatta Avenue. geconsulteam@gmail.com www.geconsultarchitects.com P.O Box 103525 - 00101 Nairobi,Kenya Tel:+254 724 008 839 / +254 725 178 875

GOOF GADUUD

**ADMINISTRATION** 


Client: **Implementation Partner:** 


> **SOMALIA STABILIZATION INITIATIVE (SSI)**

#### **Project title:**

PROPOSED GOOF GUDUUD SUB DISTRICT COMMUNITY CENTRE

#### Revision No. Drawing Tittle: OFFICE & CONFERENCE HALL ELEVATIONS 00 Scale: Sheet No. Checked & Approved by: Drawn by: A.K. Hassan Abdisamad **ARCHITECTURAL DRAWINGS** May 2017 Date:

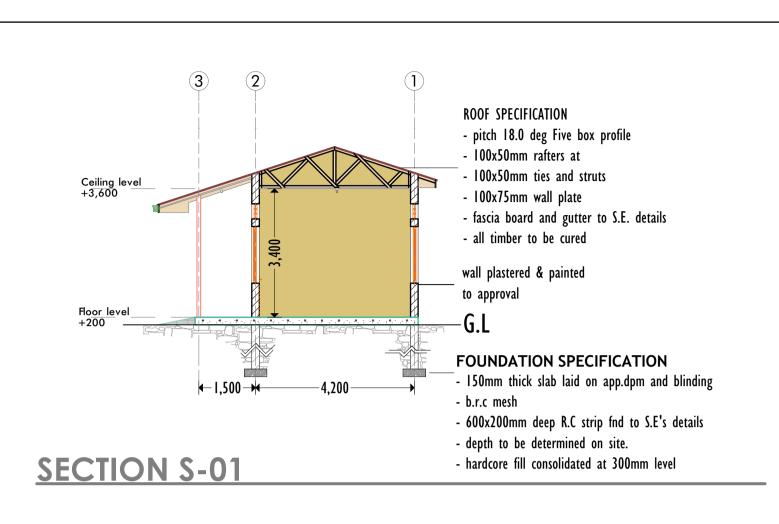

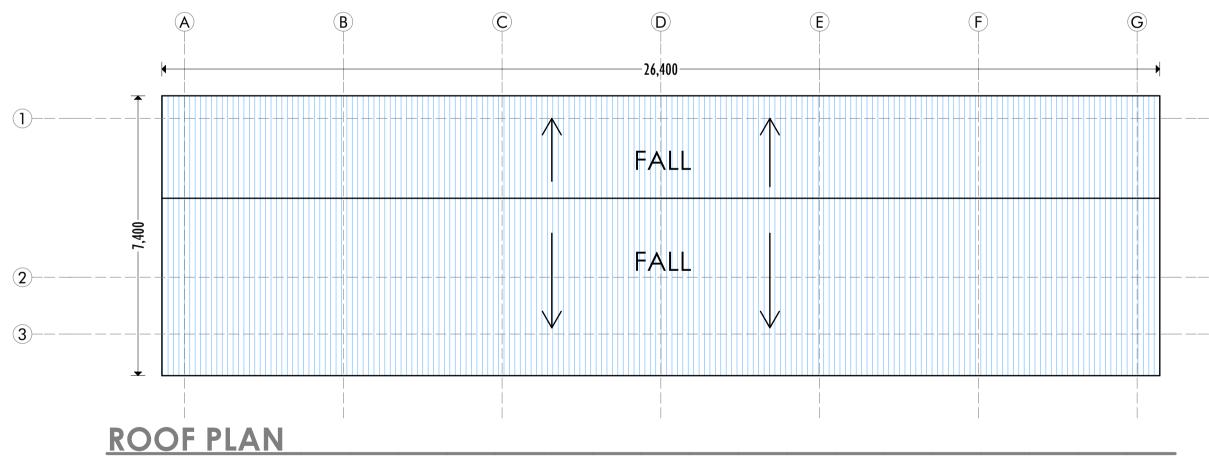

# ARCHITECTS CONSULT ARCHITECTURE 6 ENGINEERING CONSULTANTS

# GeConsult ARCHITECTURE & ENGINEERING CONSULTANTS Clien

Office No. 529,
5th Floor, 680 Hotel Building,
Muindi Mbingu Street,
Off Kenyatta Avenue.
geconsulteam@gmail.com
www.geconsultarchitects.com
P.O Box 103525 - 00101 Nairobi,Kenya
Tel:+254 724 008 839 / +254 725 178 875

## **PROJECT DETAILS**

Client: Implementation Partner:

GOOF GADUUD SOMALIA STABILIZATION ADMINISTRATION INITIATIVE (SSI)

#### Project title:

PROPOSED GOOF GUDUUD
SUB DISTRICT COMMUNITY CENTRE

## OFFICE & CONFERENCE HALL SECTION & ROOF PLAN


Revision No.

Drawn by:	Checked & Approved by:
A.K.	Hassan Abdisamad

Sheet No.

Scale:

Date: May 2017 ARCHITECTURAL DRAWINGS

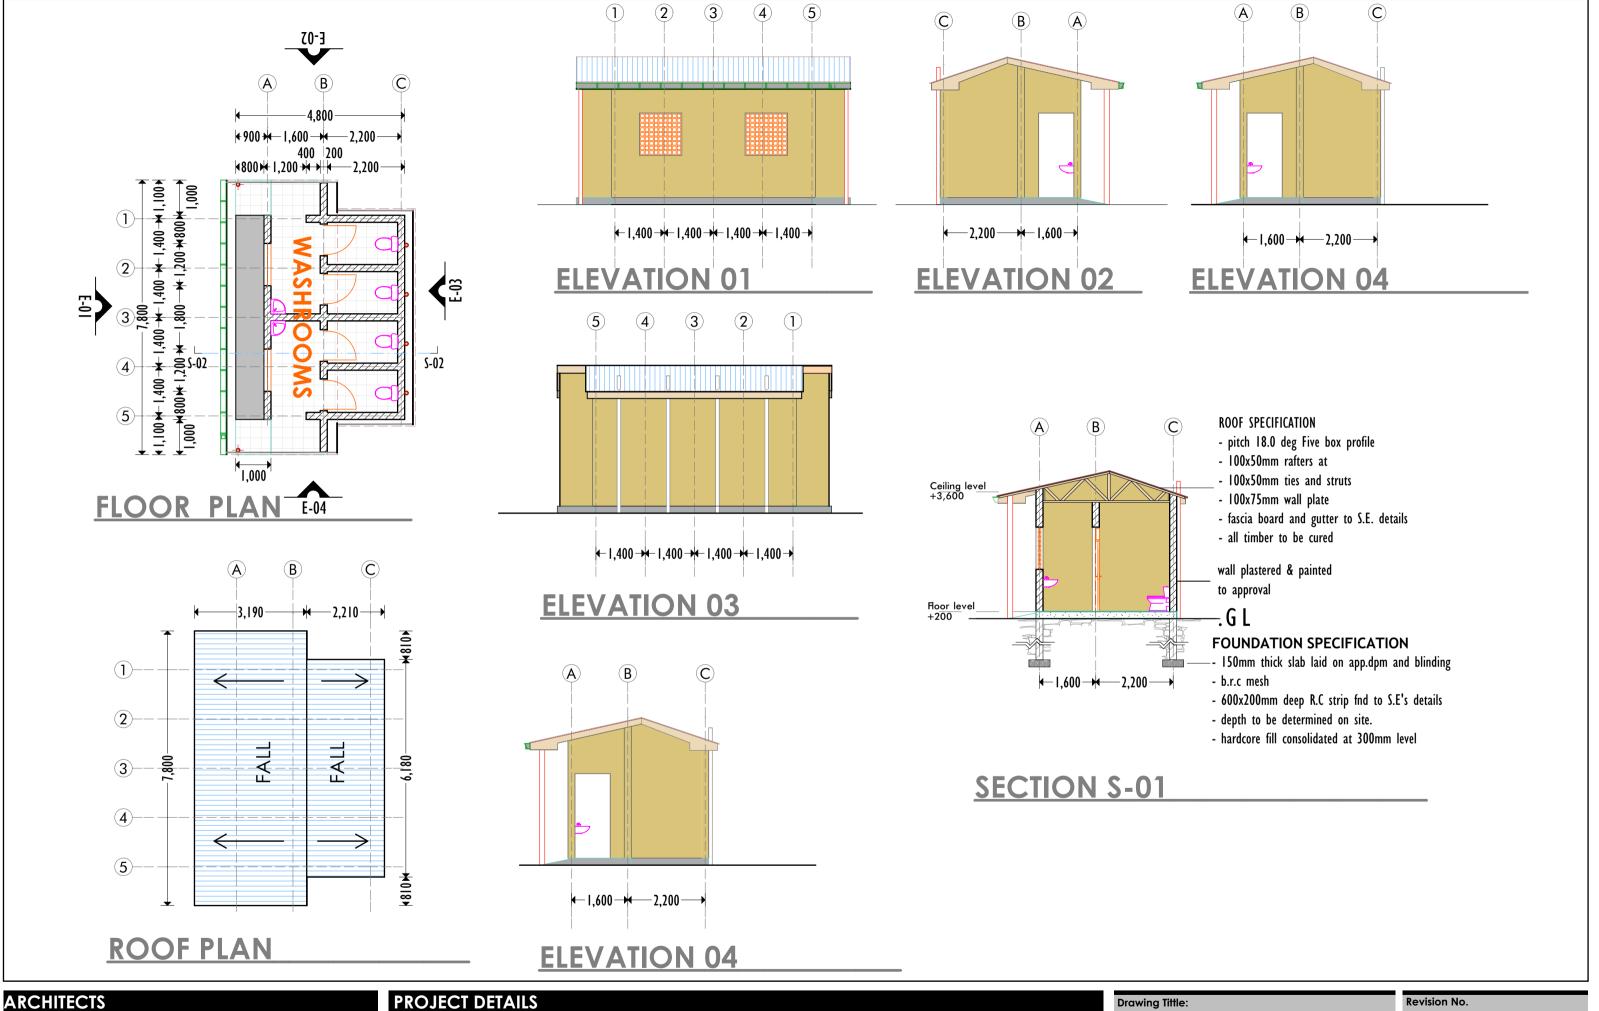



#### **GeConsult**

ARCHITECTURE & ENGINEERING CONSULTANTS

Office No. 529, 5th Floor, 680 Hotel Building, Muindi Mbingu Street, Off Kenyatta Avenue. geconsulteam@gmail.com www.aeconsultarchitects.com P.O Box 103525 - 00101 Nairobi, Kenya

Client:

**GOOF GADUUD ADMINISTRATION** 

#### **Implementation Partner:**

**SOMALIA STABILIZATION** 

**INITIATIVE (SSI)** 


Project title:


PROPOSED GOOF GUDUUD SUB DISTRICT COMMUNITY CENTRE

#### WASHROOMS 00 Scale: Checked & Approved by: Sheet No. Drawn by: Hassan Abdisamad A.K.


May 2017


Date:

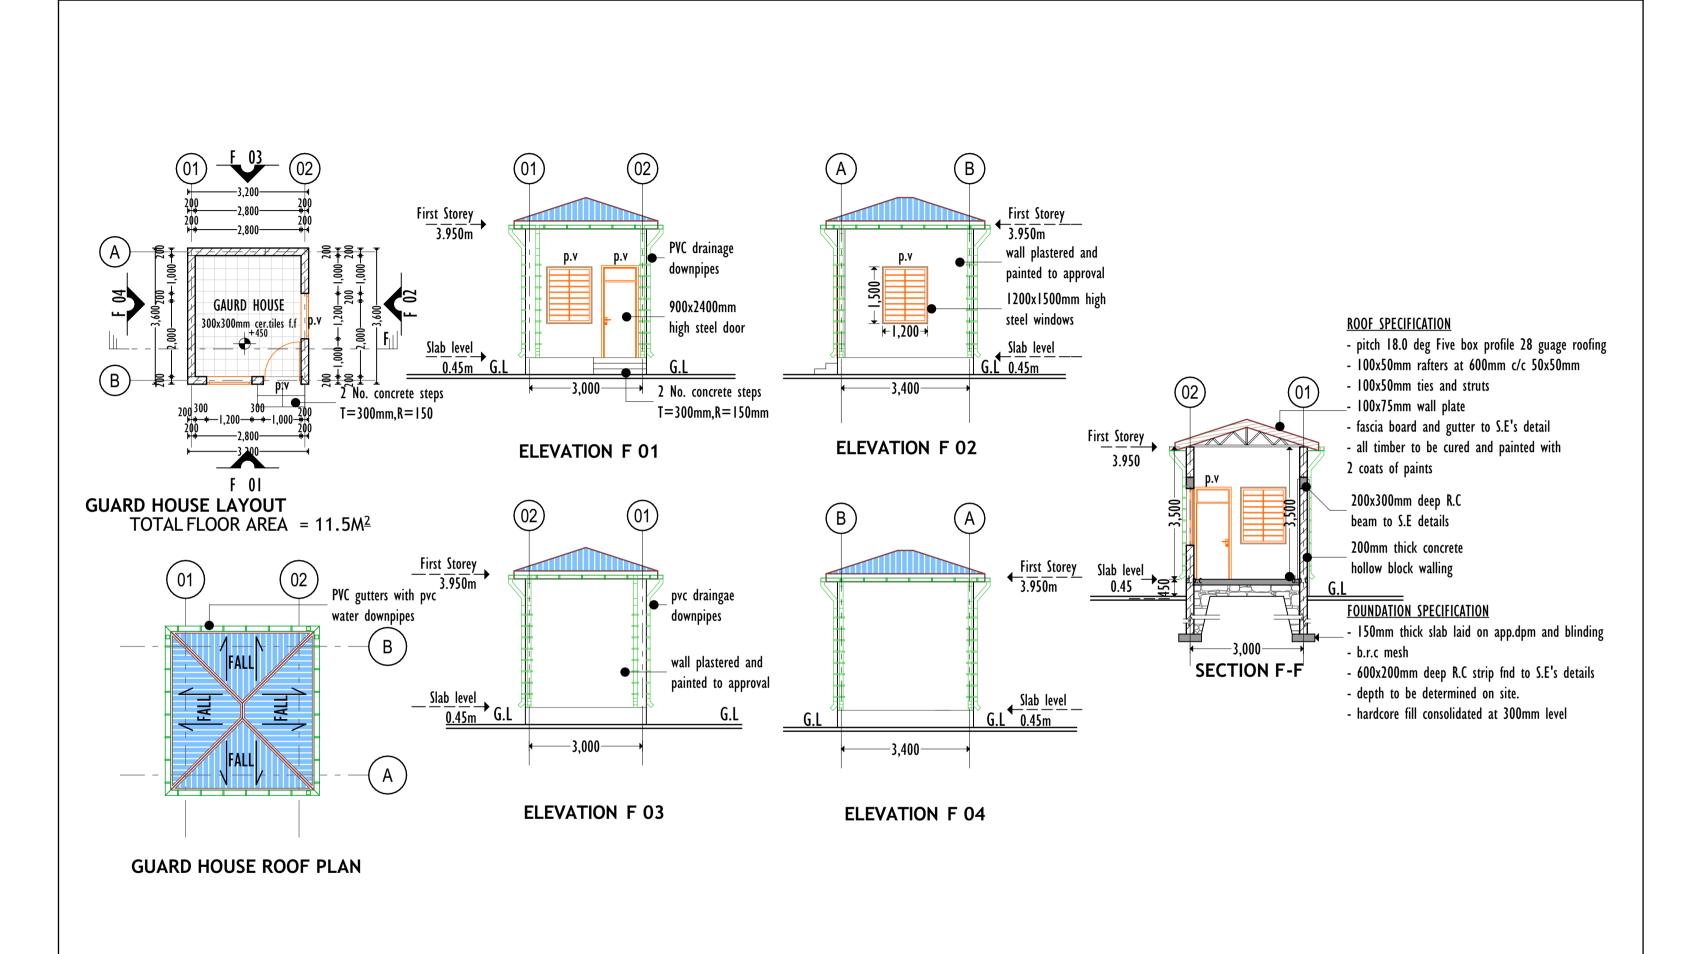


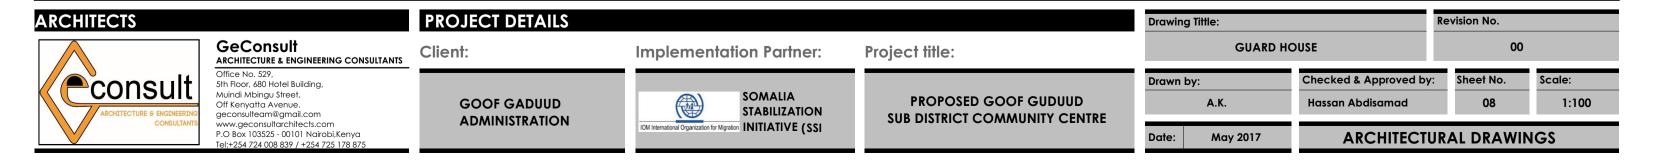


	DOOR / WINDOW SCHEDULES							
TYPE	QUANTITY	SI	ZE	MATERIAL	FINISH	IRONMONGERY		
		WIDTH	HEIGHT			HINGES	LOCKS	HANDLES
Main Doors	7	900	2,400	Metallic- steel	Painted to Specs'	4 SS heavy duty butt hinges as per UNION specs	4 lever lock system as per UNION specs	19mm Tubular SS handle as per UNION specs
Wooden doors	2	900	2,400	Wooden	Painted to Specs'	3 SS butt hinges as per UNION specs	4 lever lock system as per UNION specs	Tubular SS handle as per UNION specs
Window 1	14	1,200	1,500	Steel & Glass	Painted to Specs'	2 SS butt hinges as per UNION specs	1 latch lock	Tubular SS handle as per UNION specs
Ventilation Blocks 1	14	1,200	400	Precast Concrete	Painted to Specs'	fixed	fixed	fixed
Ventilation Blocks 2	6	900	400	Precast Concrete	Painted to Specs'	fixed	fixed	fixed
Ventilation Blocks	2	1,200	1,200	Precast Concrete	Painted to Specs	fixed	fixed	fixed

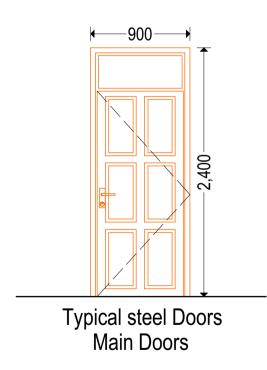

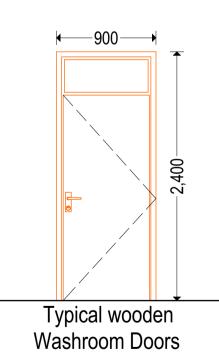

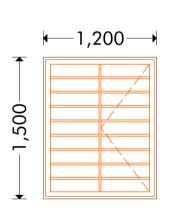

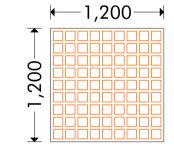

**←**1,200→

**←**1,200→

Typical Alluminium and glass window 1 Guard house/ Offices windows

**Typical Ventilation Block Window** Washroom windows **Typical Ventilation Block Window** Above windows

Typical Ventilation **Block Window** Above doors

## **ARCHITECTS**



GeConsult
ARCHITECTURE & ENGINEERING CONSULTANTS

Office No. 529, 5th Floor, 680 Hotel Building, off Noor, 880 Hotel Bullaling, Muindi Mbingu Street, Off Kenyatta Avenue. geconsulteam@gmail.com www.geconsultarchitects.com P.O Box 103525 - 00101 Nairobi,Kenya Tel:+254 724 008 839 / +254 725 178 875

## PROJECT DETAILS

GOOF GADUUD

**ADMINISTRATION** 

**Implementation Partner:** Client:

> SOMALIA STABILIZATION SOMALIA STABILIZATION
>
> IOM International Organization for Migration
>
> INITIATIVE (SSI

#### Project title:

PROPOSED GOOF GUDUUD SUB DISTRICT COMMUNITY CENTRE

rawing Tittle:			Revision No.				
GUARD HOUSE				00			
Orawn I	by: A.K.	Checked & Approved by:	:	Sheet No.	Scale: 1:100		
Date:	May 2017	ARCHITECTURAL DRAWINGS					

	AREA SCHEDU	JLES			
AREA	SIZE	FLOOR FINISH	SKIRTING	WALL FINISH	CEILING FINISH
Offices (Total for 4 Offices)	66.4M <sup>2</sup>	300mm x 300mm Ceramic tiles	150mm (H) Ceramic tiles	Painted to approval	1200mm x 2400mm Chipboards
Washrooms	25.7M <sup>2</sup>	300mm x 300mm Ceramic tiles	150mm (H) Ceramic tiles	Painted to approval	1200mm x 2400mm Chipboards
Guard House	8.9M <sup>2</sup>	300mm x 300mm Ceramic tiles	150mm (H) Ceramic tiles	Painted to approval	1200mm x 2400mm Chipboards
Conference Hall	32.8M <sup>2</sup>	300mm x 300mm Ceramic tiles	150mm (H) Ceramic tiles	Painted to approval	1200mm x 2400mm Chipboards



GeConsult
ARCHITECTURE & ENGINEERING CONSULTANTS

Office No. 529,
Sth Floor, 680 Hotel Building,
Muindi Mbingu Street,
Off Kenyatta Avenue.
geconsulteam@gmail.com
www.geconsultarchitects.com
P.O Box 103525 - 00101 Nairobi,Kenya
Tel:+254 724 008 839 / +254 725 178 875

**PROJECT DETAILS** 

Client:

Implementation Partner:

IOM International Organization for Migration INITIATIVE (SSI

SOMALIA

STABILIZATION

Project title:

PROPOSED GOOF GUDUUD

Drawing Tittle: GUARD HOUSE Revision No.

Checked & Approved by: Sheet No. Drawn by: A.K. Hassan Abdisamad


1:100

Scale:

**ARCHITECTURAL DRAWINGS** May 2017

GOOF GADUUD **ADMINISTRATION** 

SUB DISTRICT COMMUNITY CENTRE

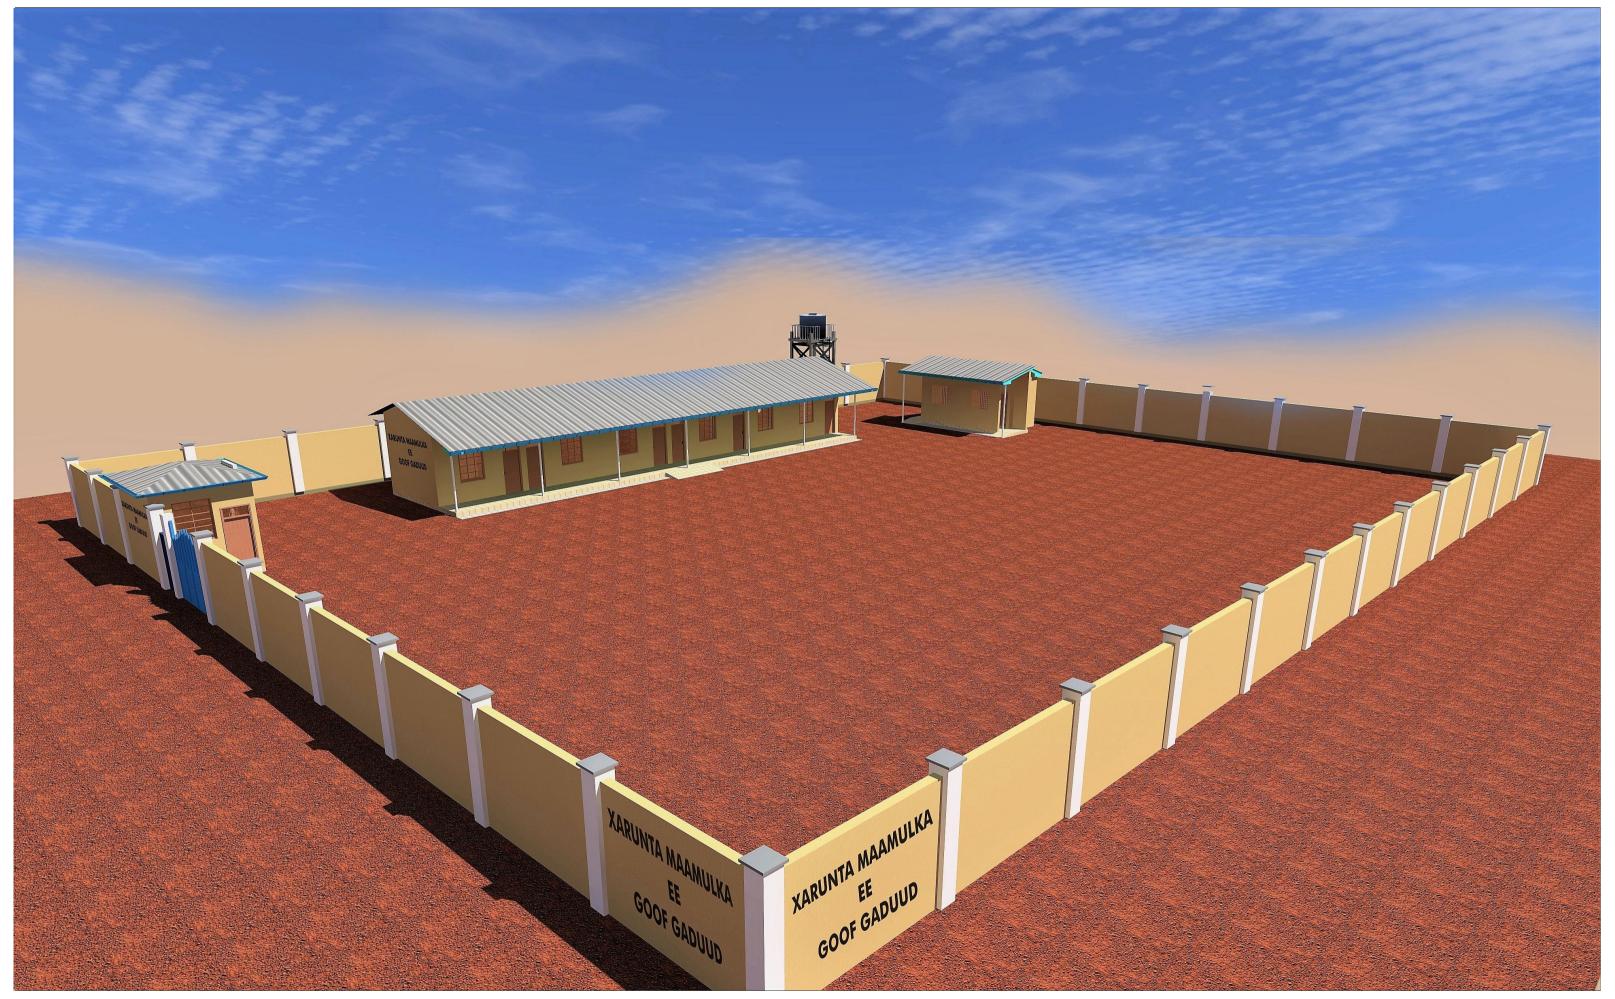



GeConsult
ARCHITECTURE & ENGINEERING CONSULTANTS

Office No. 529,
Sth Floor, 680 Hotel Building,
Muindi Mbingu Street,
Off Kenyatta Avenue,
geconsulteam@gmail.com
www.geconsultarchitects.com
P.O Box 103525 - 00101 Nairobi,Kenya
Tel:+254 724 008 839 / +254 725 178 875

## PROJECT DETAILS

GOOF GADUUD

**ADMINISTRATION** 

Client:

Implementation Partner:

SOMALIA STABILIZATION INITIATIVE (SSI)

Project title:

PROPOSED GOOF GUDUUD SUB DISTRICT COMMUNITY CENTRE Drawing Tittle: 3 DIMENSIONAL PROJECTION

Revision No. 00

Checked & Approved by: Drawn by: A.K. Hassan Abdisamad

Scale: Sheet No.

ARCHITECTURAL DRAWINGS May 2017 Date:





GeConsult
ARCHITECTURE & ENGINEERING CONSULTANTS

Office No. 529,
Sth Floor, 680 Hotel Building,
Muindi Mbingu Street,
Off Kenyatta Avenue.
geconsulteam@gmail.com
www.geconsultarchitects.com
P.O Box 103525 - 00101 Nairobi,Kenya
Tel:+254 724 008 839 / +254 725 178 875

## PROJECT DETAILS

GOOF GADUUD

**ADMINISTRATION** 

Client:

Implementation Partner:

SOMALIA STABILIZATION

INITIATIVE (SSI)

Project title:


PROPOSED GOOF GUDUUD SUB DISTRICT COMMUNITY CENTRE 3 DIMENSIONAL PROJECTION

Revision No. 00

Checked & Approved by: Drawn by: A.K. Hassan Abdisamad

Scale: Sheet No.

May 2017

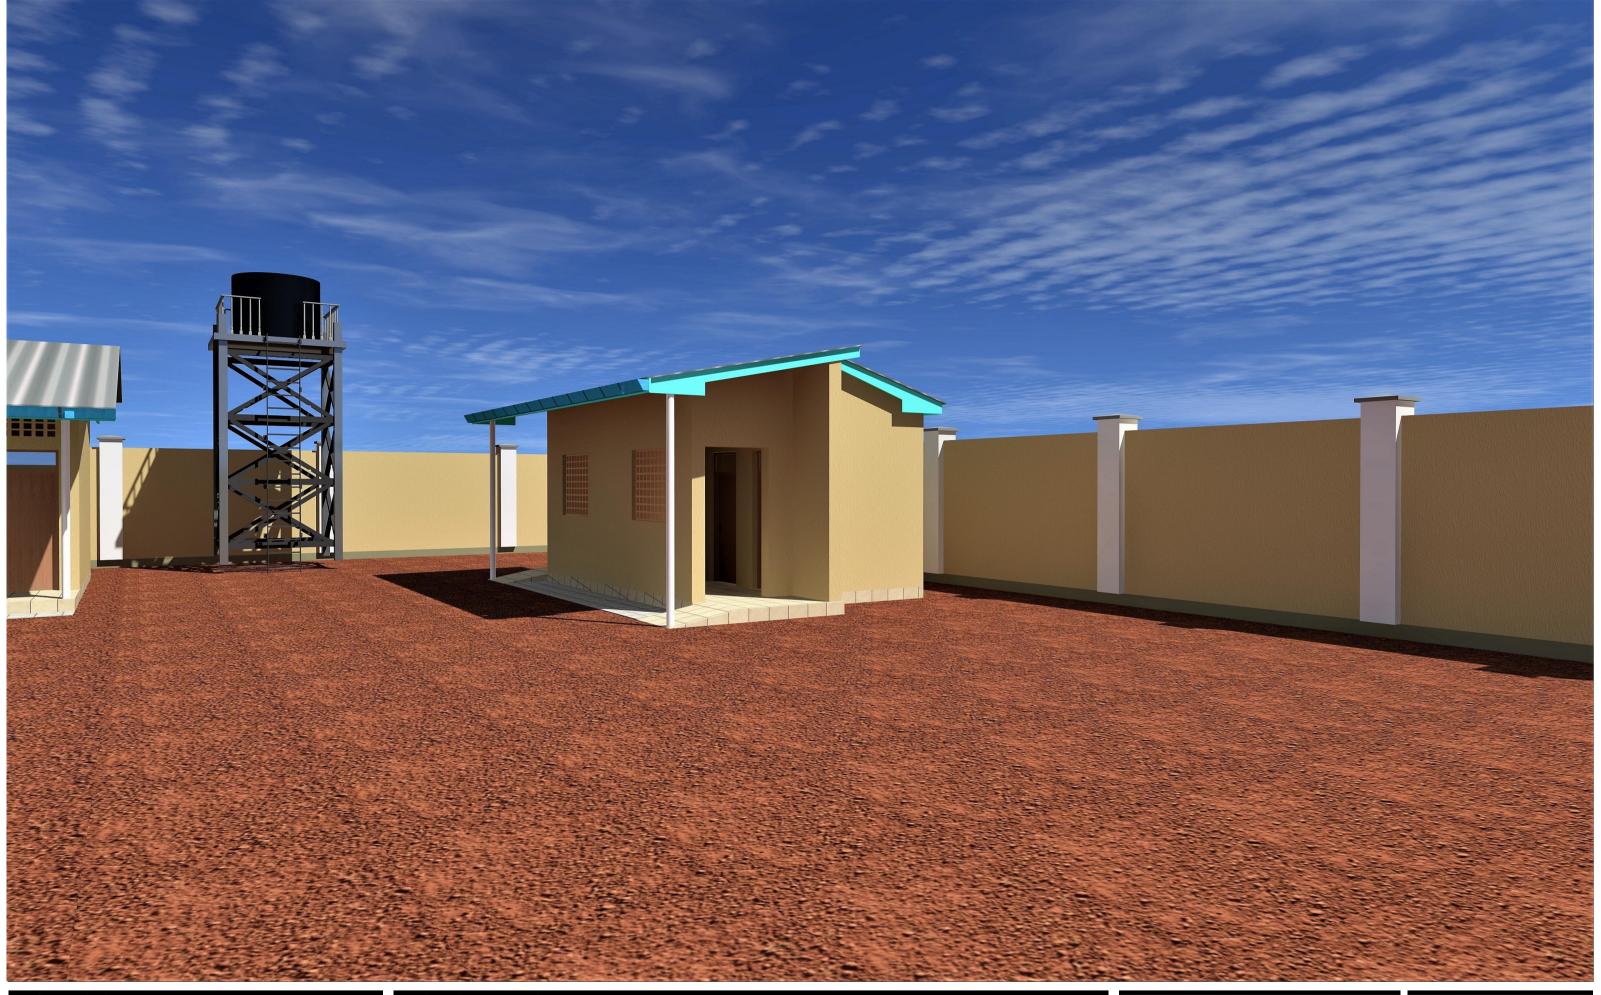



GeConsult

ARCHITECTURE & ENGINEERING CONSULTANTS

Office No. 529,
5th Floor, 680 Hotel Building,
Muindi Mbingu Street,
Off Kenyatta Avenue.
geconsulteam@gmail.com
www.geconsultarchitects.com
P.O Box 103525 - 00101 Nairobi,Kenya
Tel:+254 724 008 839 / +254 725 178 875

## PROJECT DETAILS

GOOF GADUUD

**ADMINISTRATION** 

Client:

**Implementation Partner:** 

SOMALIA STABILIZATION INITIATIVE (SSI)

Project title:

PROPOSED GOOF GUDUUD SUB DISTRICT COMMUNITY CENTRE

Drawing Tittle:				
3 DIMENSIONAL PROJECTION				

Revision No. 00

Checked & Approved by: Sheet No. Drawn by: A.K. Hassan Abdisamad

Scale:

Date: May 2017





GeConsult
ARCHITECTURE & ENGINEERING CONSULTANTS

Office No. 529,
Sth Floor, 680 Hotel Building,
Muindi Mbingu Street,
Off Kenyatta Avenue.
geconsulteam@gmail.com
www.geconsultarchitects.com
P.O Box 103525 - 00101 Nairobi,Kenya
Tel;+254 724 008 839 / +254 725 178 875

## **PROJECT DETAILS**

GOOF GADUUD

**ADMINISTRATION** 

Client:

Implementation Partner:

SOMALIA STABILIZATION INITIATIVE (SSI)

Project title:

PROPOSED GOOF GUDUUD SUB DISTRICT COMMUNITY CENTRE 3 DIMENSIONAL PROJECTION

Revision No. 00

Checked & Approved by: Drawn by: A.K. Hassan Abdisamad

Scale: Sheet No.

May 2017





GeConsult
ARCHITECTURE & ENGINEERING CONSULTANTS

ARCHITECTURE & ENGINEERING CONS
Office No. 529,
5th Floor, 680 Hotel Building,
Muindi Mbingu Street,
Off Kenyatta Avenue,
geconsulteam@gmail.com
www.geconsultarchitects.com
P.O Box 103525 - 00101 Nairobi.Kenya
Tel;+254 724 008 839 / +254 725 178 875

## PROJECT DETAILS

GOOF GADUUD

**ADMINISTRATION** 

Client:

Implementation Partner:

SOMALIA STABILIZATION INITIATIVE (SSI)

Project title:

PROPOSED GOOF GUDUUD SUB DISTRICT COMMUNITY CENTRE Drawing Tittle: 3 DIMENSIONAL PROJECTION

Revision No. 00

Checked & Approved by: Drawn by: A.K. Hassan Abdisamad

Scale: Sheet No.

May 2017 Date:





Office No. 529,
5th Floor, 680 Hotel Building,
Muindi Mbingu Street,
Off Kenyatta Avenue.
geconsulteam@gmail.com
www.geconsultarchites.com P.O Box 103525 - 00101 Nairobi, Kenya Tel:+254 724 008 839 / +254 725 178 873

Client:

**Implementation Partner:** 

Project title:

**Grant No.:** 


Content:

GOOF GADUUD **ADMINISTRATION**  SOMALIA STABILIZATION INITIATIVE (SSI)

PROPOSED GOOF GUDUUD SUB DISTRICT COMMUNITY CENTRE

**BAI041** 

**MECHANICAL DRAWINGS** 

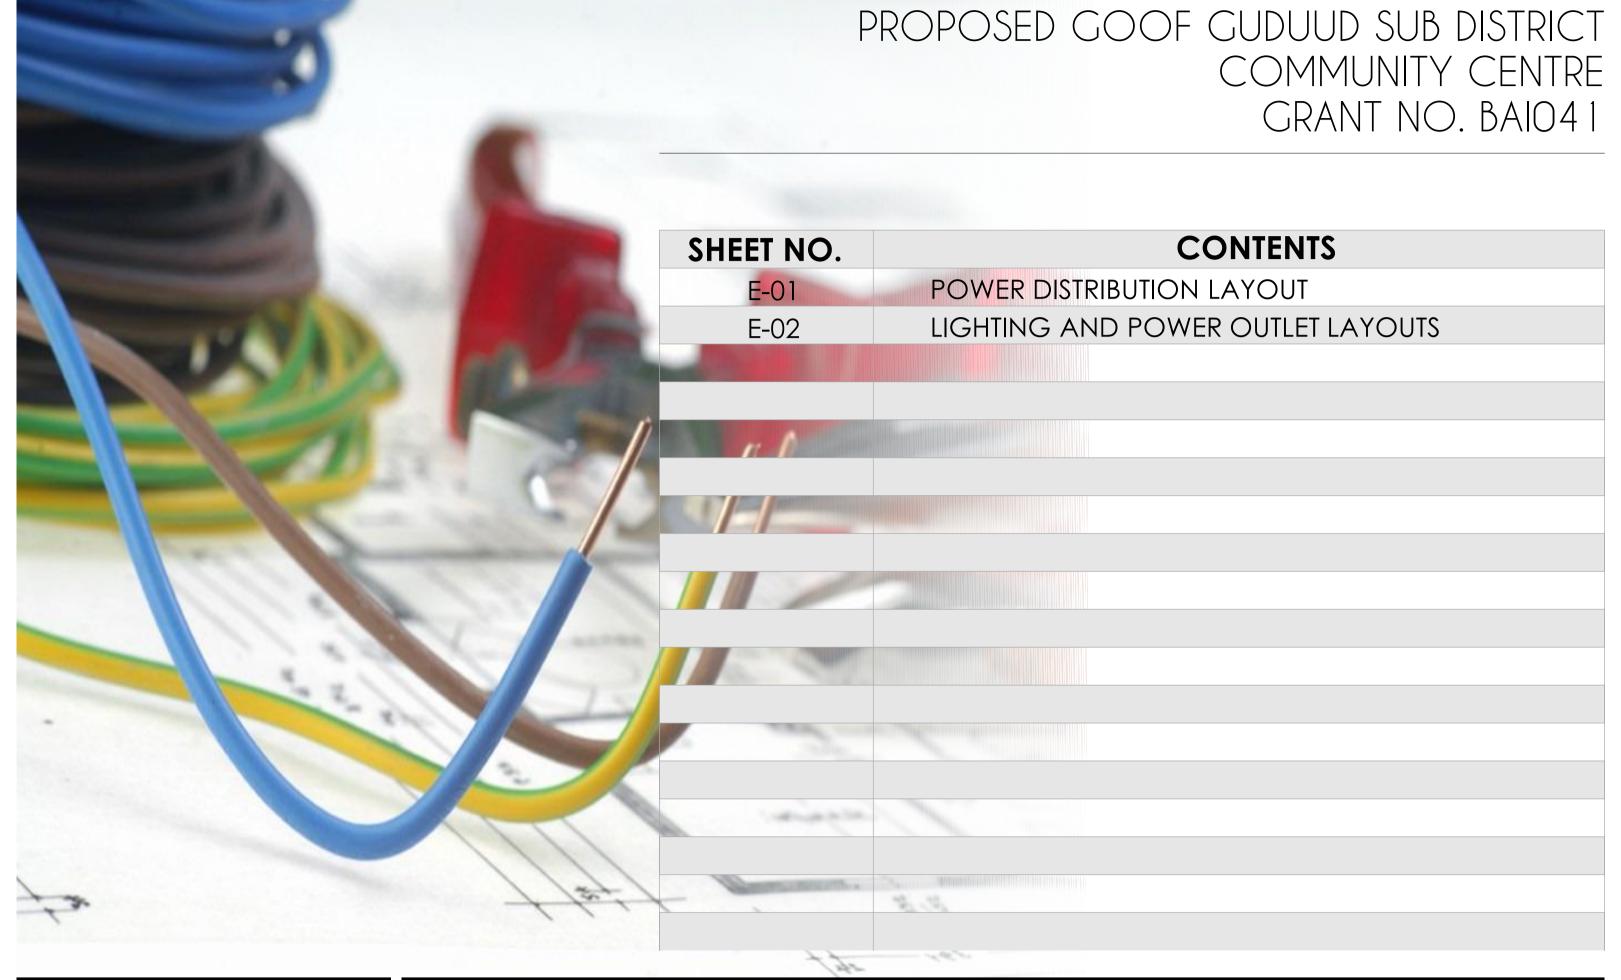



## GeConsult ARCHITECTURE & ENGINEERING CONSULTANTS

Office No. 529, 5th Floor, 680 Hotel Building, Muindi Mbingu Street, Off Kenyatta Avenue. geconsulteam@gmail.com www.geconsultarchitects.com P.O Box 103525 - 00101 Nairobi,Kenya

#### PROJECT DETAILS

Client:

GOOF GADUUD

**ADMINISTRATION** 

SOMALIA STABILIZATION

IOM International Organization for Migration

INITIATIVE (SSI)

**Implementation Partner:** 

Project title:

PROPOSED GOOF
GUDUUD
SUB DISTRICT
COMMUNITY CENTRE

Location:

ion. Gi

Goof Gaduud,


Lower Juba Region

SOMALIA

BAI041

Grant No.: Content:

**ELECTRICAL DRAWINGS** 

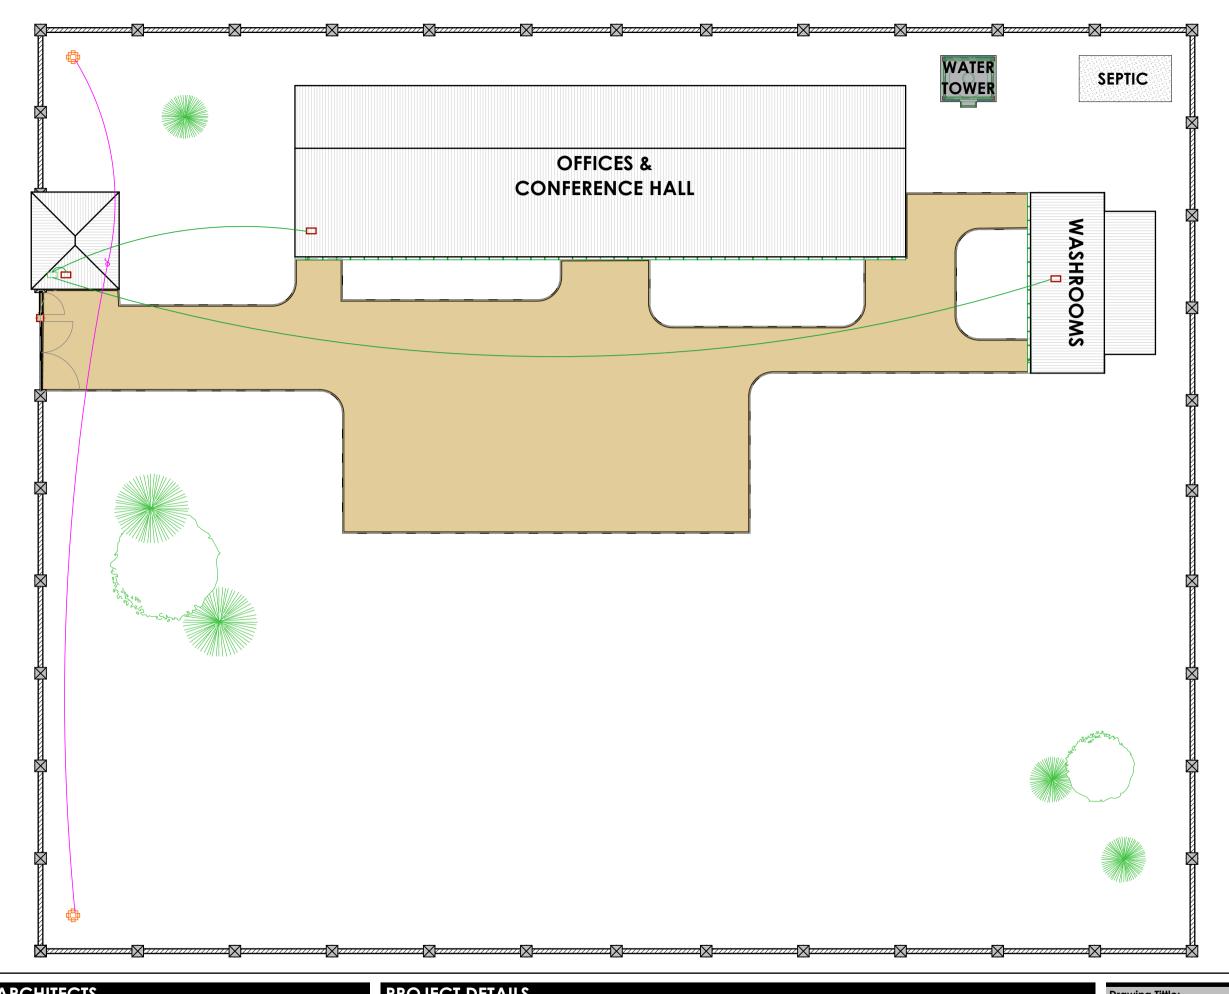

## **LEGEND**

	4FT Flourescent Light
$\otimes$	Point Light
$\leftarrow$	Twin Sockets with Switch
	Consumer Unit
	Power outlet circuit
	Lighting circuit
	Lighting mains
d	I gang I way switch
	Power mains to CU
	Main Distribution Board
	Floodlights

## **ARCHITECTS**

<u> Consult</u>

GeConsult
ARCHITECTURE & ENGINEERING CONSULTANTS

Office No. 529,
Sth Floor, 680 Hotel Building,
Muindi Mbingu Street,
Off Kenyatta Avenue,
geconsulteam@gmail.com
www.geconsultarchitects.com
P.O Box 103525 - 00101 Nairobi,Kenya
Tel:+254 724 008 839 / +254 725 178 875

## **PROJECT DETAILS**

GOOF GADUUD

**ADMINISTRATION** 

Client:

SOMALIA STABILIZATION IOM International Organization for Migration INITIATIVE (SSI

Implementation Partner:

#### **Project title:**

PROPOSED GOOF GUDUUD SUB DISTRICT COMMUNITY CENTRE

## POWER DISTRIBUTION LAYOUT

Checked & Approved by: Hassan Abdisamad

Sheet No. Scale: E-01 1:100


May 2017 Date:

A.K.

Drawn by:

**ELECTRICAL DRAWINGS** 

Revision No.

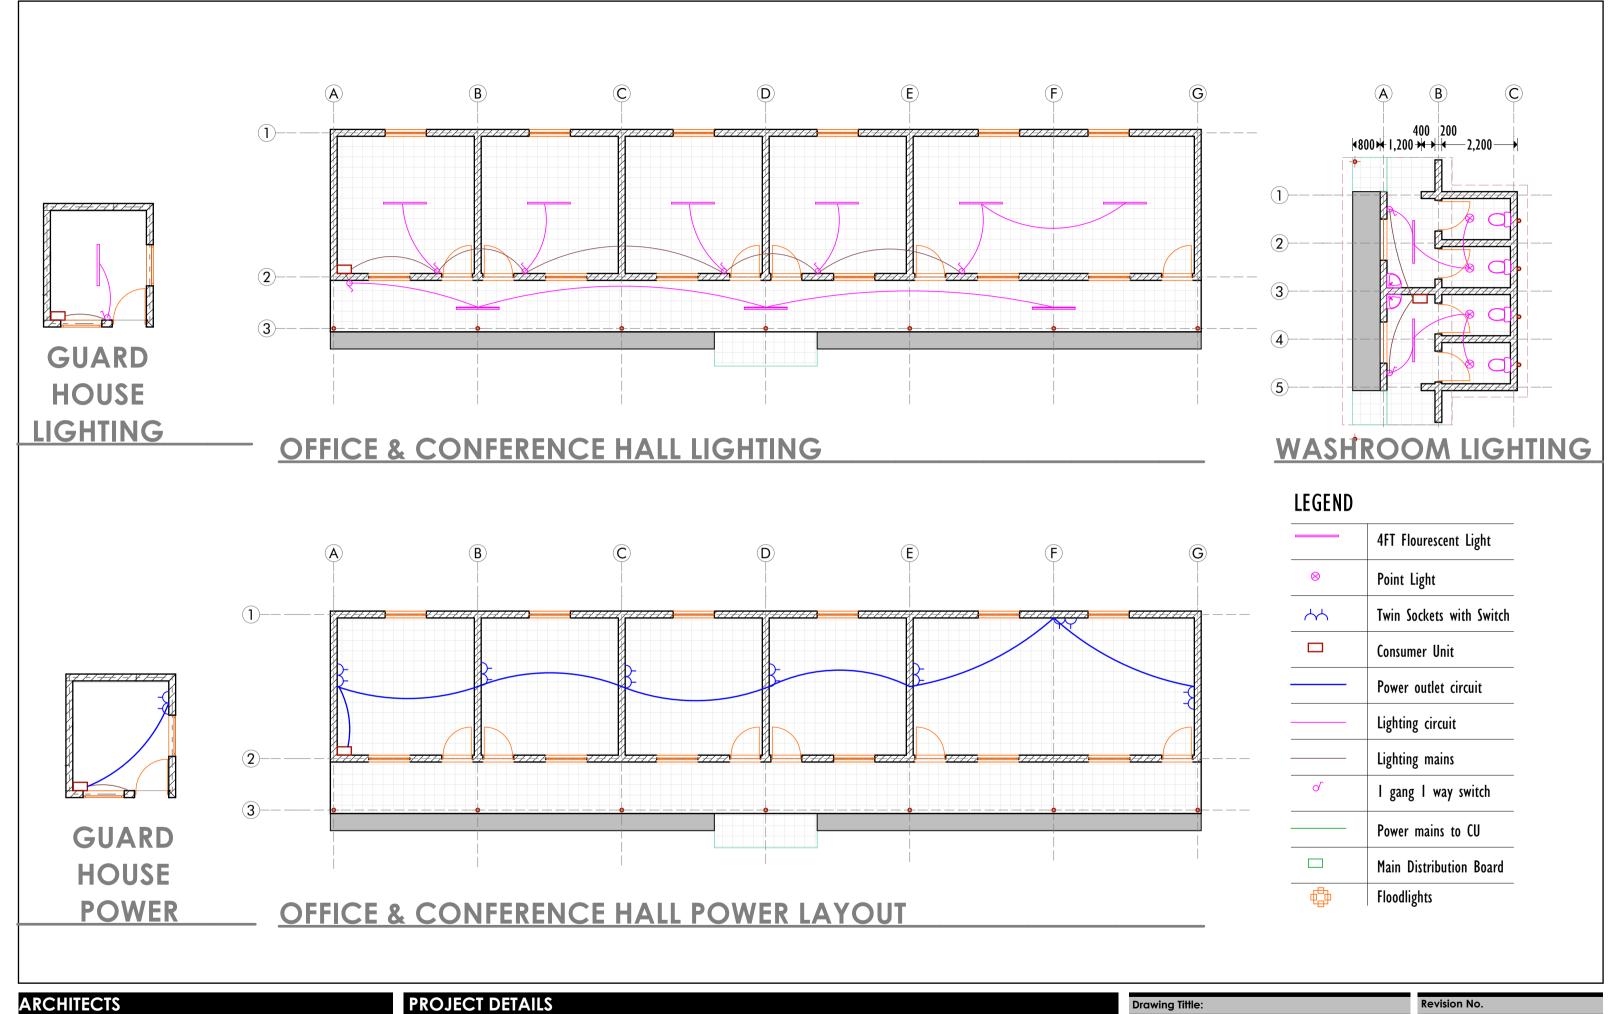



#### **GeConsult** Client:

ARCHITECTURE & ENGINEERING CONSULTANTS Office No. 529, 5th Floor, 680 Hotel Building, Muindi Mbingu Street, Off Kenyatta Avenue. geconsulteam@gmail.com vww.aeconsultarchitects.com P.O Box 103525 - 00101 Nairobi, Kenya

GOOF GADUUD **ADMINISTRATION** 

#### **Implementation Partner:**



#### Project title:

PROPOSED GOOF GUDUUD SUB DISTRICT COMMUNITY CENTRE


# LIGHTING AND POWER OUTLET LAYOUTS


Revision No. 00

Scale:

Drawn by:	Checked & Approved by:	Sheet No.
A.K.	Hassan Abdisamad	E-02

**ELECTRICAL DRAWINGS** Date: May 2017

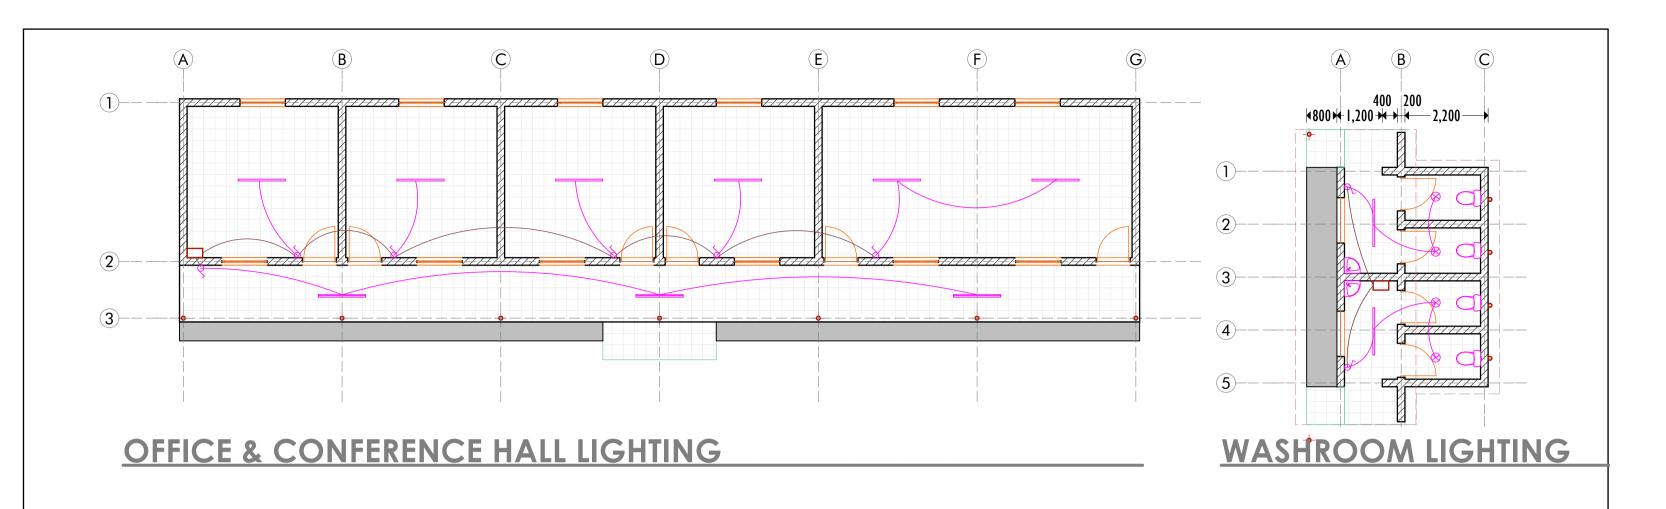

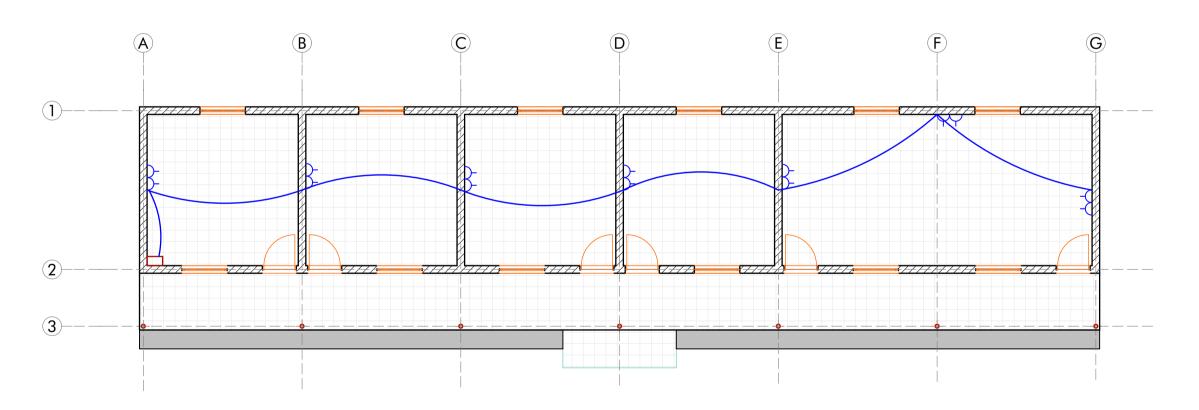

# LEGEND

	4FT Flourescent Light
$\otimes$	Point Light
$\leftarrow$	Twin Sockets with Switch
	Consumer Unit
_	Power outlet circuit
	Lighting circuit
	Lighting mains
0	I gang I way switch

## OFFICE & CONFERENCE HALL POWER LAYOUT

# CONSULTANCE OF ENGINEERING CONSULTANTS

#### **GeConsult**

ARCHITECTURE & ENGINEERING CONSULTANTS

Office No. 529,
5th Floor, 680 Hotel Building,
Muindi Mbingu Street,
Off Kenyatta Avenue.
geconsulteam@gmail.com
www.geconsultarchitects.com
P.O Box 103525 - 00101 Nairobi,Kenya
Tel:+254 724 008 839 / +254 725 178 875

## **PROJECT DETAILS**

GOOF GADUUD

**ADMINISTRATION** 

Client:

**Implementation Partner:** 

SOMALIA STABILIZATION INITIATIVE (SSI)

#### Project title:

PROPOSED GOOF GUDUUD
SUB DISTRICT COMMUNITY CENTRE

# OFFICE & WASHROOMS ELECRTRICAL DRAWINGS

Revision No.

Drawn by:

Checked & Approved by:

Hassan Abdisamad

Sheet No. Scale: E-01

Date: May 2017

**ELECTRICAL DRAWINGS** 





Office No. 529,
5th Floor, 680 Hotel Building,
Muindi Mbingu Street,
Off Kenyatta Avenue.
geconsulteam@gmail.com
www.geconsultarchites.com P.O Box 103525 - 00101 Nairobi, Kenya Tel:+254 724 008 839 / +254 725 178 873

Client:

**Implementation Partner:** 

Project title:

**Grant No.:** 


Content:

GOOF GADUUD **ADMINISTRATION**  SOMALIA STABILIZATION INITIATIVE (SSI)

PROPOSED GOOF GUDUUD SUB DISTRICT COMMUNITY CENTRE

**BAI041** 

**MECHANICAL DRAWINGS** 

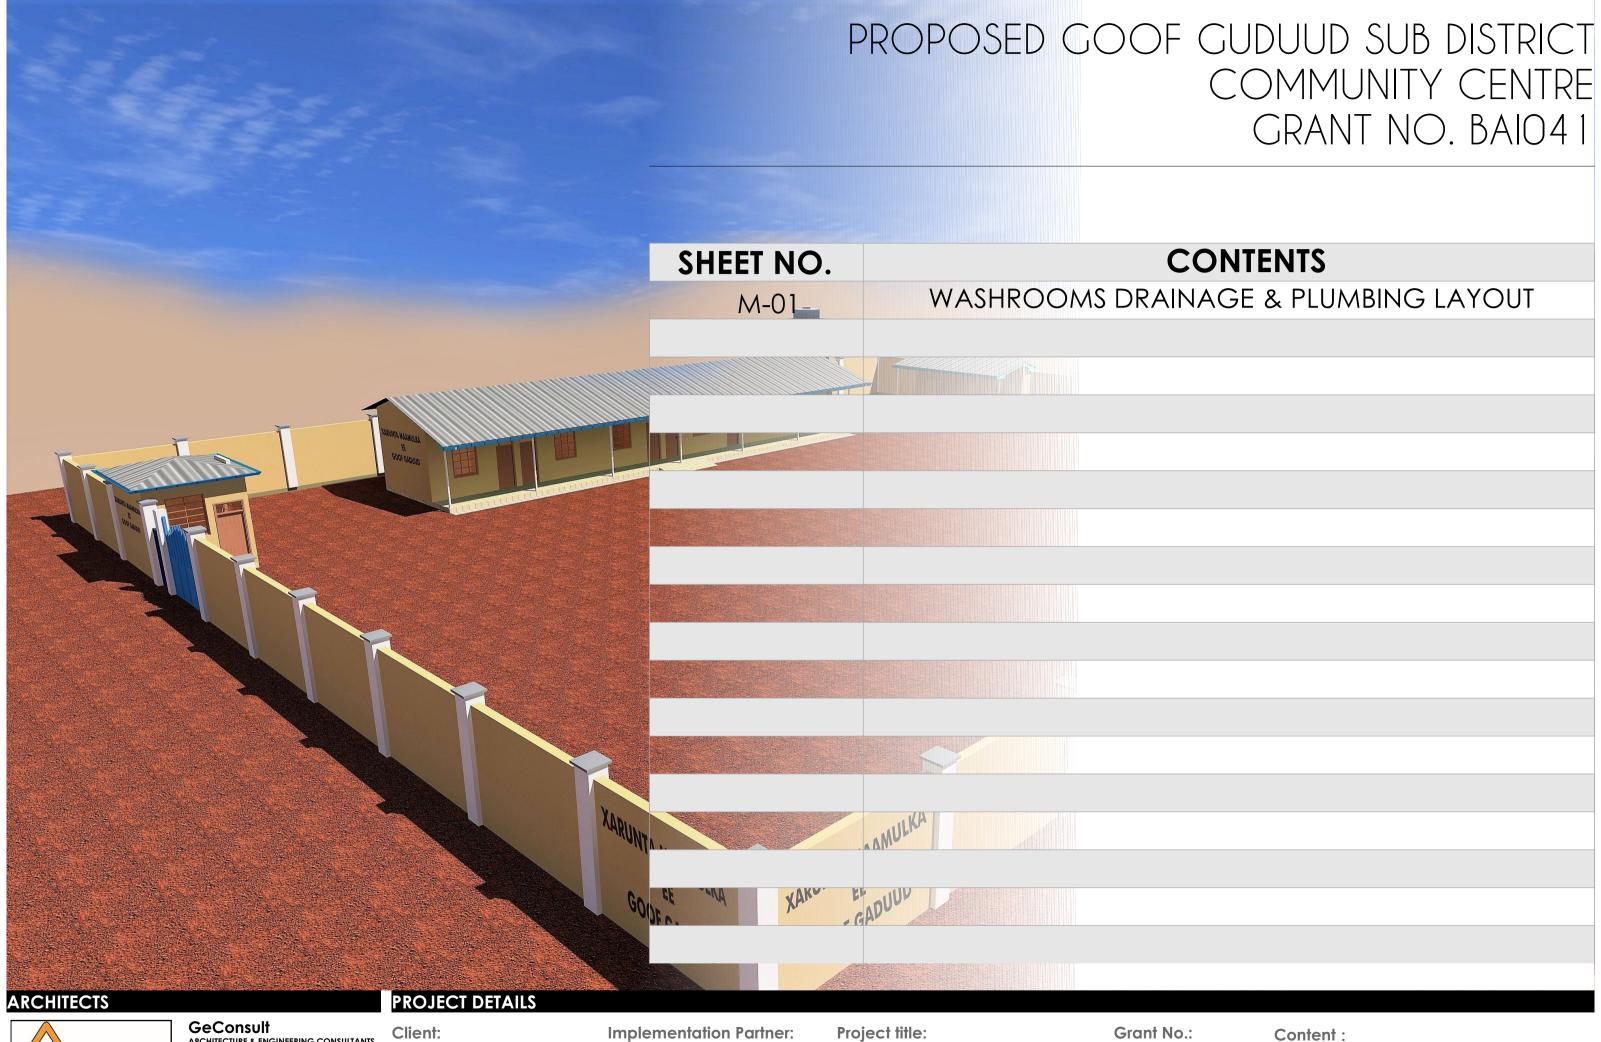

<u> Consult</u>

ARCHITECTURE & ENGINEERING CONSULTANTS Office No. 529. 5th Floor, 680 Hotel Building,

Muindi Mbingu Street, Off Kenyatta Avenue. geconsulteam@gmail.com www.geconsultarchitects.com P.O Box 103525 - 00101 Nairobi,Kenya **Implementation Partner:** 


Content:

GOOF GADUUD **ADMINISTRATION**  **SOMALIA STABILIZATION INITIATIVE (SSI)** 

PROPOSED GOOF GUDUUD SUB DISTRICT COMMUNITY CENTRE

**BAI041** 

**MECHANICAL DRAWINGS** 

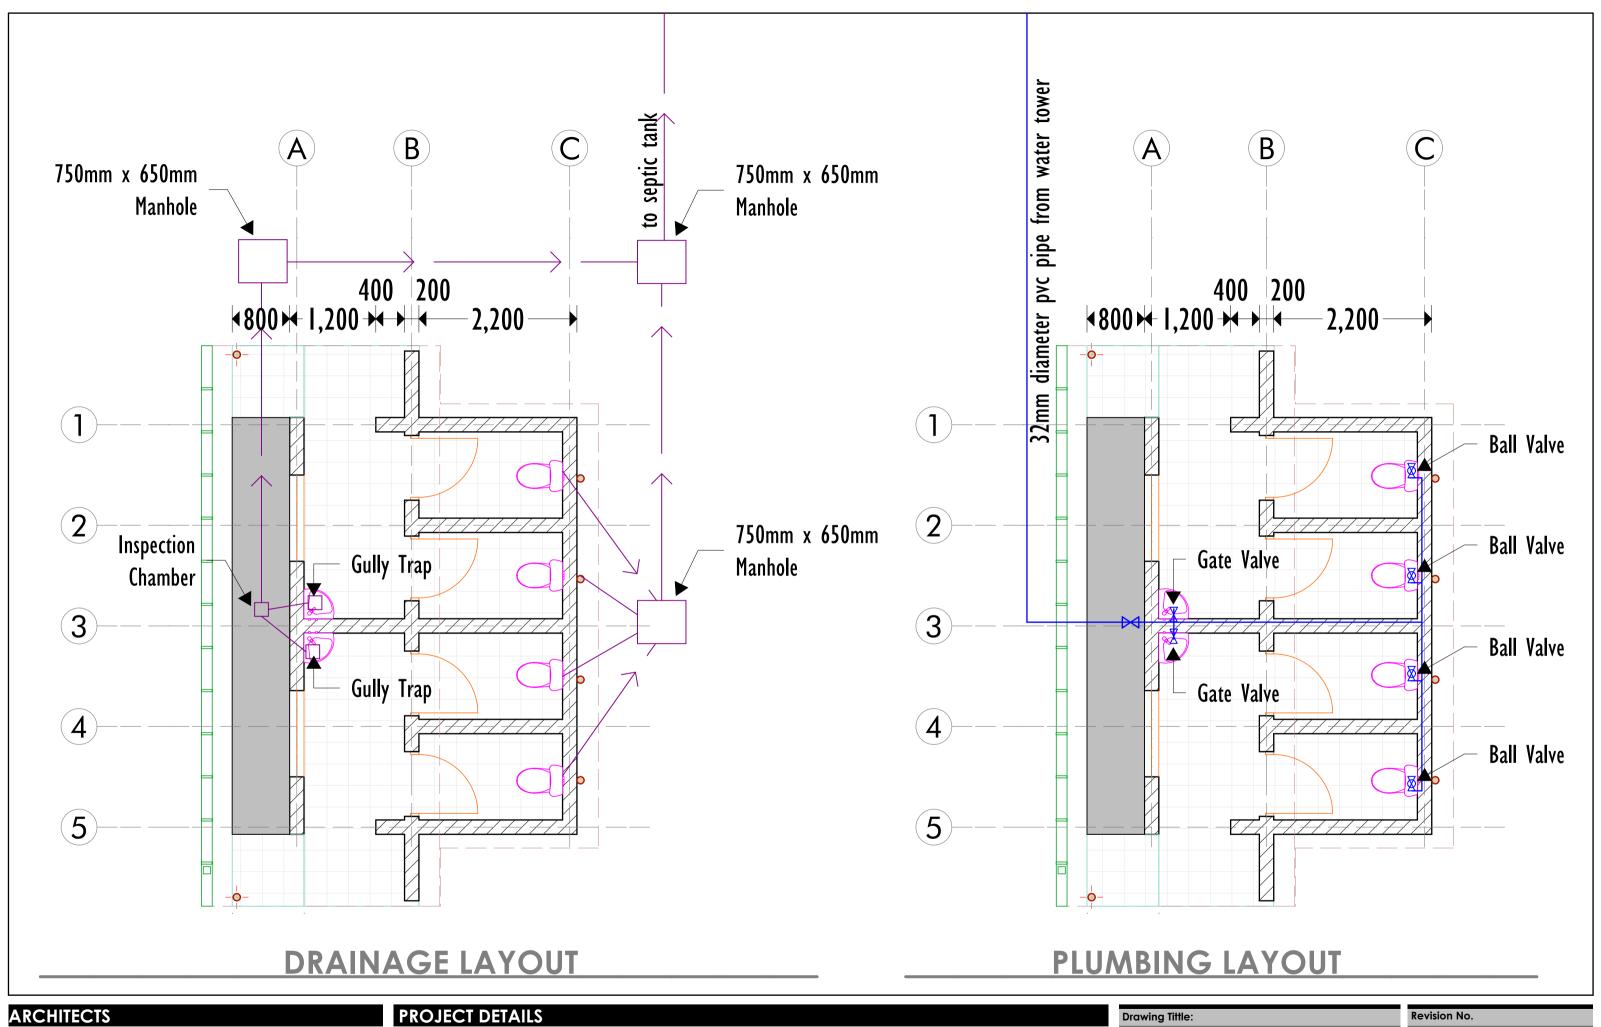



Office No. 529, 5th Floor, 680 Hotel Building, Muindi Mbingu Street, Off Kenyatta Avenue. geconsulteam@gmail.com www.geconsultarchitects.com P.O Box 103525 - 00101 Nairobi,Kenya Tel:+254 724 008 839 / +254 725 178 875

**GOOF GADUUD** 

**ADMINISTRATION** 

Client: **Implementation Partner:** 

> **SOMALIA STABILIZATION** INITIATIVE (SSI)

**Project title:** 

PROPOSED GOOF GUDUUD SUB DISTRICT COMMUNITY CENTRE

Revision No. **WASHROOMS PLUMBING & DRAINAGE LAYOUT** Checked & Approved by: Drawn by:

Sheet No. Scale: A.K. Hassan Abdisamad M-01 May 2017 **MECHANICAL DRAWINGS** Date:

00





Office No. 529,
Sth Floor, 680 Hotel Building,
Muindi Mbingu Street,
Off Kenyatta Avenue.
geconsulteam@gmail.com
www.geconsultarchitects.com
P.O Box 103525 - 00101 Nairobi,Kenya
Tel:+254 724 008 839 / +254 725 178 875

Client:

GOOF GADUUD

**ADMINISTRATION** 

**Implementation Partner:** 

SOMALIA STABILIZATION IOM International Organization for Migration INITIATIVE (SSI)


PROPOSED GOOF GUDUUD SUB DISTRICT **COMMUNITY CENTRE**  Location:

Goof Gaduud, Lower Juba Region SOMALIA

Grant No.: Content:

**BAI041** 

**STRUCTURAL DRAWINGS** 

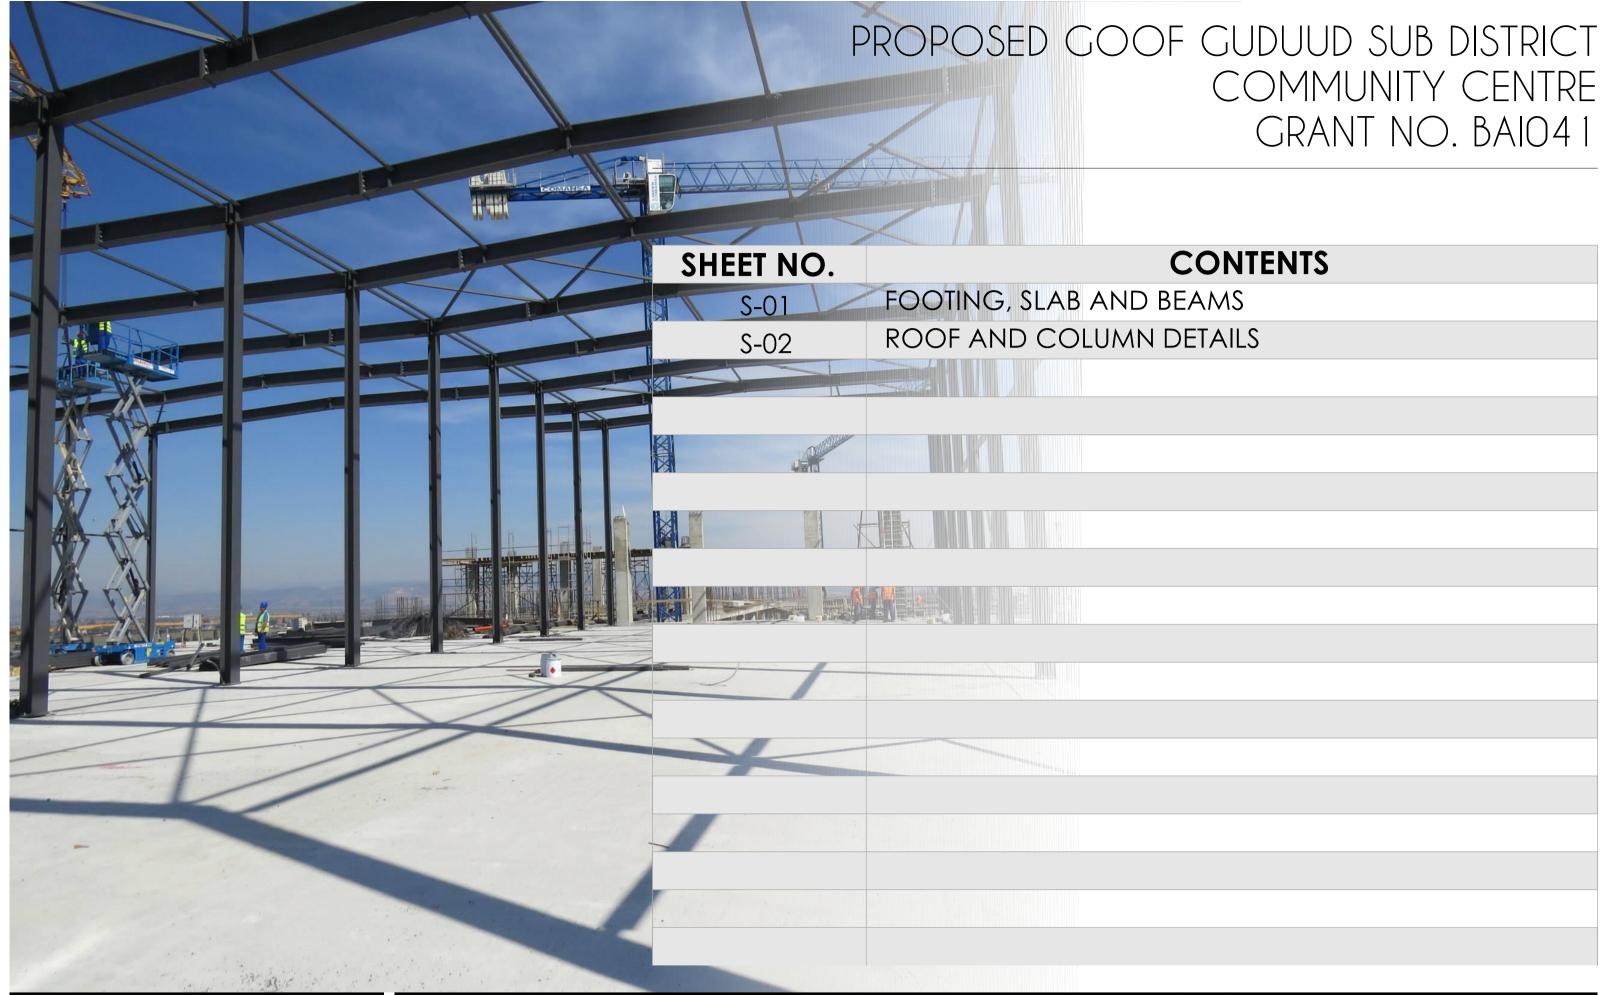



GeConsult
ARCHITECTURE & ENGINEERING CONSULTANTS

Office No. 529, 5th Floor, 680 Hotel Building, Muindi Mbingu Street, Off Kenyatta Avenue. geconsulteam@gmail.com www.geconsultarchitects.com P.O Box 103525 - 00101 Nairobi, Kenya Tel:+254 724 008 839 / +254 725 178 873

#### PROJECT DETAILS

Client:

**Implementation Partner:** 

SOMALIA STABILIZATION IOM International Organization for Migration INITIATIVE (SSI) **Project title:** 

PROPOSED GOOF

Location:

Grant No.: Content:

**BAI041** 


**STRUCTURAL DRAWINGS** 


GOOF GADUUD **ADMINISTRATION** 

GUDUUD SUB DISTRICT **COMMUNITY CENTRE** 

Goof Gaduud, Lower Juba Region SOMALIA



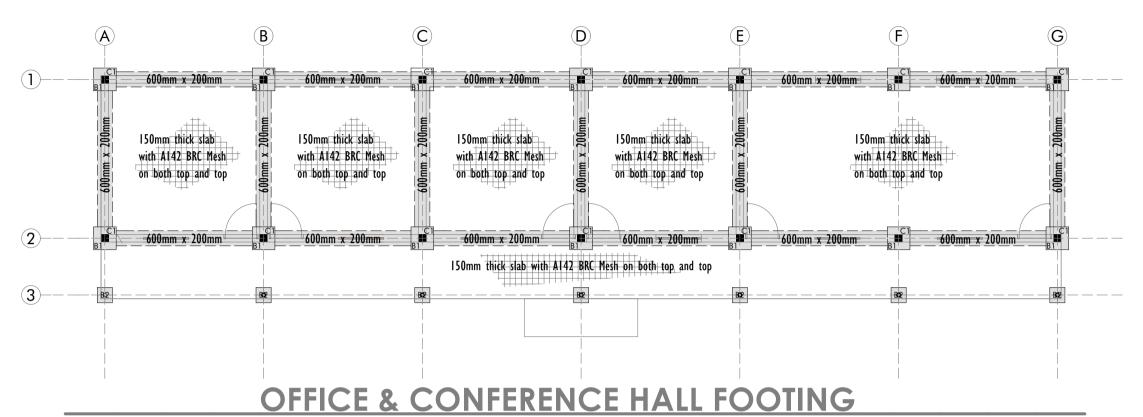

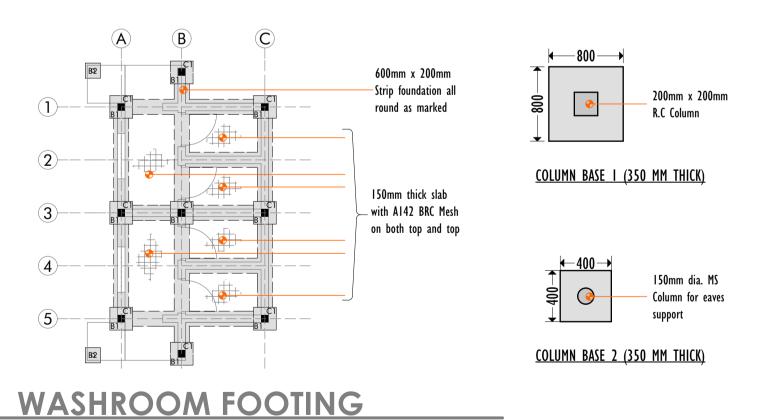



#### **GeConsult**

ARCHITECTURE & ENGINEERING CONSULTANTS

Office No. 529, 5th Floor, 680 Hotel Building, Muindi Mbingu Street, Off Kenyatta Avenue. geconsulteam@gmail.com www.geconsultarchitects.com P.O Box 103525 - 00101 Nairobi,Kenya Tel:+254 724 008 839 / +254 725 178 875

#### **PROJECT DETAILS**

GOOF GADUUD

**ADMINISTRATION** 

Client:

**Implementation Partner:** 

**Project title:** 

PROPOSED GOOF GUDUUD

#### Drawing Tittle: WASHROOM, OFFICE & CONFERENCE HALL FOOTING

Revision No. 00

Scale:

1:100

Sheet No.


S-01

Drawn by:	Checked & Approved by:
A.K.	Hassan Abdisamad

May 2017 STRUCTURAL DRAWINGS Date:

**SOMALIA STABILIZATION INITIATIVE (SSI)** 

SUB DISTRICT COMMUNITY CENTRE

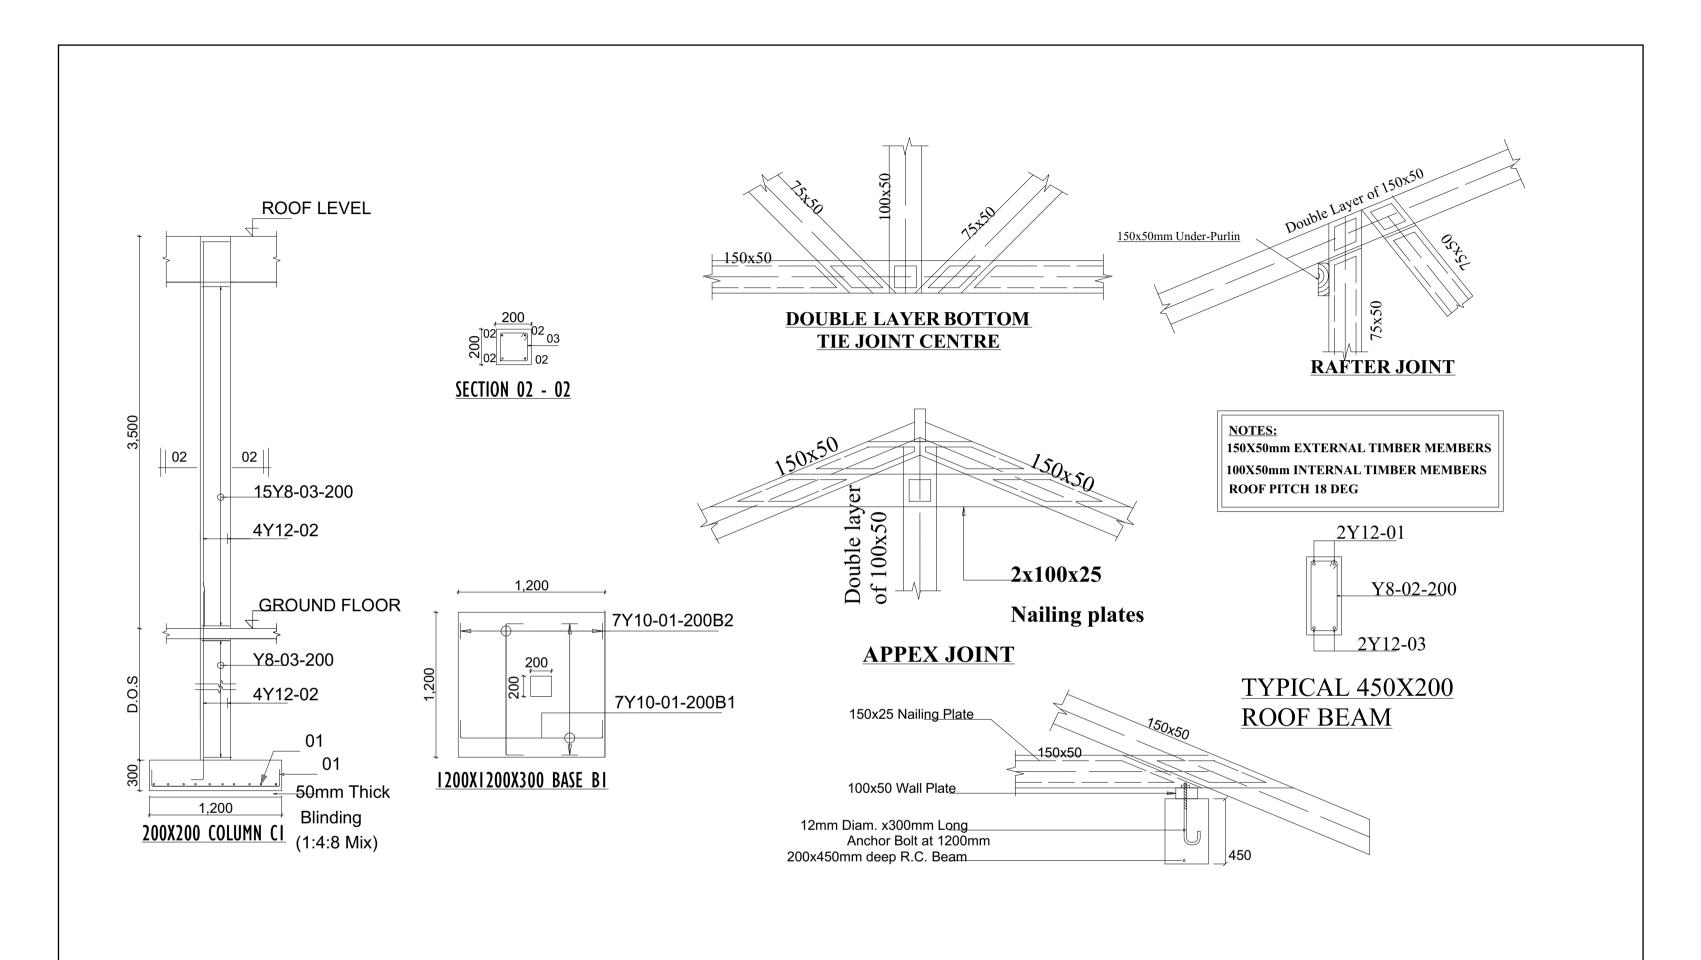



## PROJECT DETAILS

Client:

Implementation Partner:

Project title:

PROPOSED GOOF GUDUUD
SUB DISTRICT COMMUNITY CENTRE

Drawing Tittle:			Re	evision No.			
ROOF AND COLUMN DETAILS				00			
Orawn by:		Checked & Approved by Hassan Abdisamad	<b>/:</b>	Sheet No.         Scale:           \$-02         1:100			
Date:	May 2017	STRUCTURAL DRAWINGS					

GOOF GADUUD ADMINISTRATION

